



UIL HOLDINGS CORPORATION

157 Church Street, New Haven CT 06510-2100
203-499-2000

Via Hand Delivery and Electronic Mail

April 23, 2015

Robert Stein
Chairman
Connecticut Siting Council
Ten Franklin Square
New Britain, CT 06051

Re: Petition No. 1120 – The United Illuminating Company Petition for a Declaratory Ruling that no Certificate of Environmental Compatibility and Public Need is Required for the Proposed Modifications to the Hawthorne Substation at 180 Hawthorne Drive, Fairfield, Connecticut

Dear Chairman Stein:

Please find enclosed the original and fifteen (15) copies of The United Illuminating Company's ("UI") revised site plan titled "Overall Plan Hawthorne Substation" in connection with the above-referenced Petition. Additionally, UI will electronically file all responses and attachments via siting.council@ct.gov.

Please do not hesitate to contact me at (203) 499-2422 if you have any questions regarding this filing.


Very truly yours,

A handwritten signature in blue ink, appearing to read 'Bruce L. McDermott', with a stylized flourish at the end.

Bruce L. McDermott
Managing Counsel – Operations
UIL Holdings Corporation
As Agent for The United Illuminating Company

cc: Service List

Enclosures

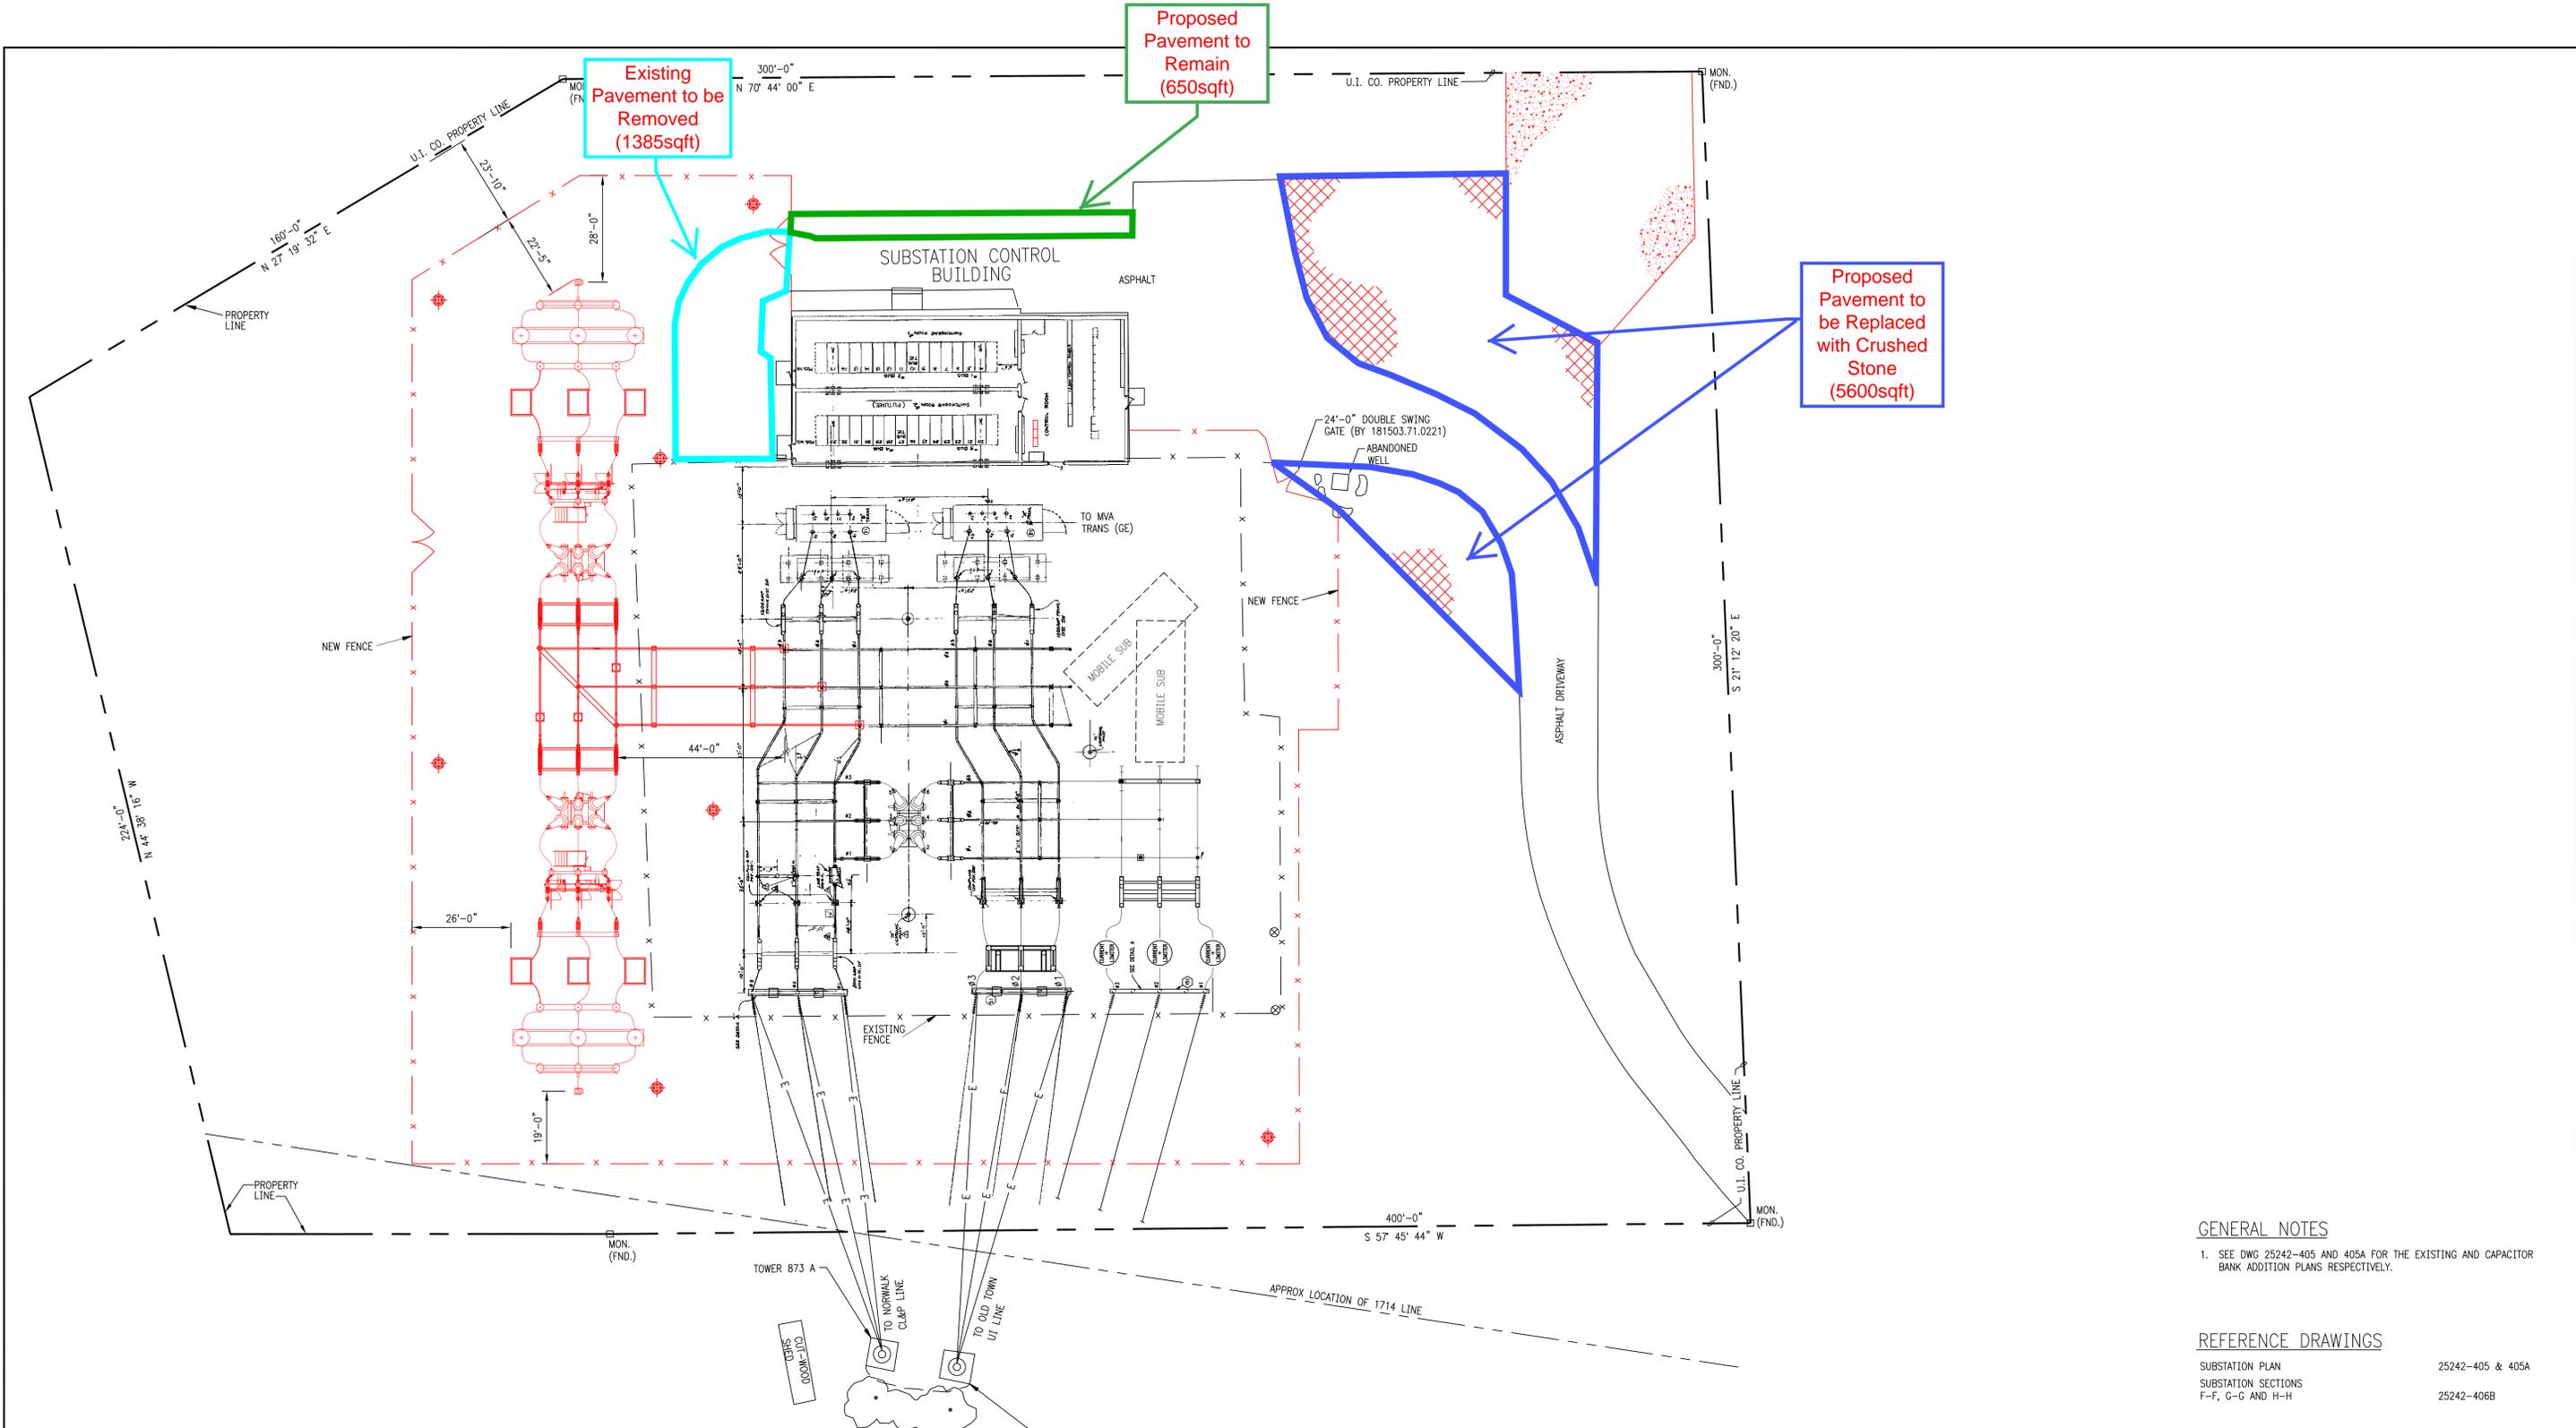


GENERAL NOTES
 1. SEE DWG 25242-405 AND 405A FOR THE EXISTING AND CAPACITOR BANK ADDITION PLANS RESPECTIVELY.

REFERENCE DRAWINGS
 SUBSTATION PLAN 25242-405 & 405A
 SUBSTATION SECTIONS F-F, G-G AND H-H 25242-406B

PRELIMINARY
 NOT TO BE USED FOR CONSTRUCTION
NEW DRAWING

BLACK & VEATCH Building a world of difference®							
DESIGNER	JDG	DRAWN	BD				
CHECKED	-	DATE	-				
PROJECT #	181503						
NO.	DATE	ISSUED FOR CSC DOCUMENTATION	REVISION	SLC	TKD	JDG	DJK
				DRN	CHKD	DESN	SUPR

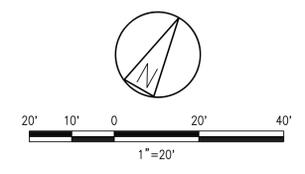

No.	Date	Revision	By	Chkd.	Engr.	Supv.

ui
 The United Illuminating Company

Drawn: _____ Date: 09/11/2014 Scale: 1"=20'
 Chkd.: _____ Design Engr.: _____ Design Supv.: _____

OVERALL PLAN		
HAWTHORNE SUBSTATION		
CAD FILE NAME	SEQUENCE No.	DRAWING NUMBER
		25242-404A