


REV.	DATE	REVISION DESCRIPTION	SHEET NO.

THE INFORMATION, INCLUDING ESTIMATED QUANTITIES OF WORK, SHOWN ON THESE SHEETS IS BASED ON LIMITED INVESTIGATIONS BY THE STATE AND IS IN NO WAY WARRANTED TO INDICATE THE CONDITIONS OF ACTUAL QUANTITIES OF WORK WHICH WILL BE REQUIRED.

Plotted Date: 11/24/2015

DESIGNER/DRAFTER: JB
 CHECKED BY: SN
 SCALE AS NOTED

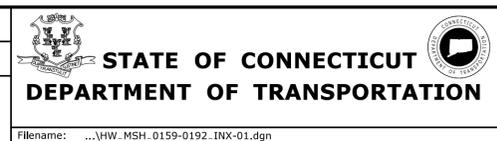

SIGNATURE/BLOCK:
 OFFICE OF ENGINEERING
 APPROVED BY:
William B. ...

PROJECT TITLE:
PAVEMENT PRESERVATION ON ROUTE 3

TOWN:
**WETHERSFIELD
 GLASTONBURY**


DRAWING TITLE:
INDEX PLAN

PROJECT NO.
159-192

DRAWING NO.
HWY-02

SHEET NO.
03.02

TYPICAL CROSS SECTION OF ROADWAY
(TREATMENT I)

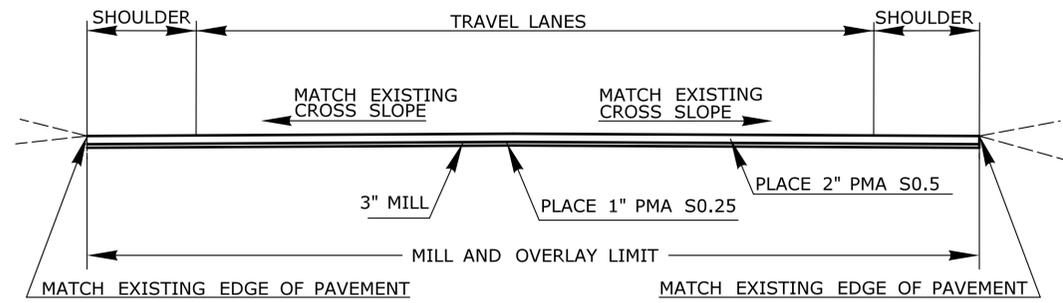


CT ROUTE - 3 NORTHBOUND & SOUTHBOUND
ROADWAY TREATMENTS FOR MM 10.38 - 10.99;
NB 12.28 - 13.98
SB 12.27 - 13.67

CONSTRUCTION NOTES:

1. POTHOLES LESS THAN 2.5" IN DEPTH AND DETERIORATED AREAS LEFT AFTER MILLING SHALL BE REPAIRED AS DETERMINED BY THE ENGINEER UNDER THE ITEM #0406125A. POTHOLES GREATER THAN 2.5" IN DEPTH SHALL BE REPAIRED AS DETERMINED BY THE ENGINEER UNDER THE ITEM #0601192A.
2. RUMBLE STRIPS SHALL BE INSTALLED AT EXISTING LOCATIONS AND AS SPECIFIED IN THE SPECIAL PROVISIONS OR AS DIRECTED BY THE ENGINEER.
3. TEMPORARY PAVEMENT MARKINGS SHALL BE REMOVED BETWEEN PAVING LIFTS.

NOT TO SCALE

TYPICAL CROSS SECTION OF ROADWAY
(TREATMENT II)

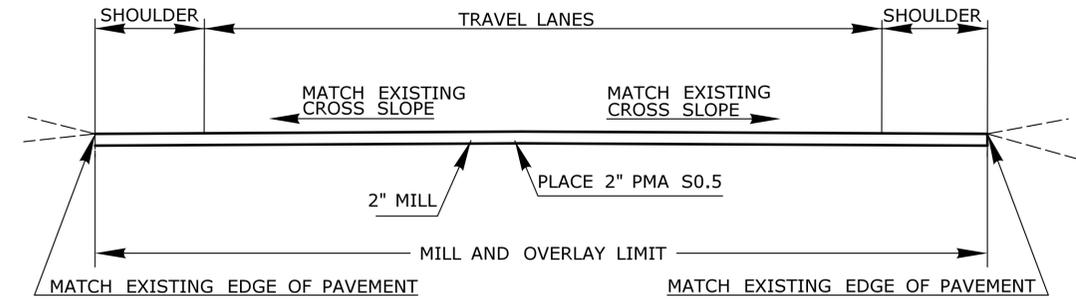


CT ROUTE - 3 NORTHBOUND & SOUTHBOUND
ROADWAY TREATMENTS FOR MM 10.99 - 11.63;
RAMPS FOR RTE 3 NB TO/FROM GLASTONBURY BLVD AND RTE 2 EB;
RTE 3 SB TO/FROM PUTNAM BLVD;
AND RTE 2 EB TO RTE 3 SB

CONSTRUCTION NOTES:

1. PRIOR TO PLACEMENT OF POLYMER MODIFIED ASPHALT, JOINT AND CRACK FILLING OF EXISTING BITUMINOUS PAVEMENT (ITEM #0406195A) SHALL BE PERFORMED.
2. POTHOLES LESS THAN 2.5" IN DEPTH AND DETERIORATED AREAS LEFT AFTER MILLING SHALL BE REPAIRED AS DETERMINED BY THE ENGINEER UNDER THE ITEM #0406125A. POTHOLES GREATER THAN 2.5" IN DEPTH SHALL BE REPAIRED AS DETERMINED BY THE ENGINEER UNDER THE ITEM #0601192A.
3. RUMBLE STRIPS SHALL BE INSTALLED AT EXISTING LOCATIONS AND AS SPECIFIED IN THE SPECIAL PROVISIONS OR AS DIRECTED BY THE ENGINEER.
4. TEMPORARY PAVEMENT MARKINGS SHALL BE REMOVED BETWEEN PAVING LIFTS.

NOT TO SCALE

TYPICAL CROSS SECTION OF ROADWAY
(TREATMENT III)

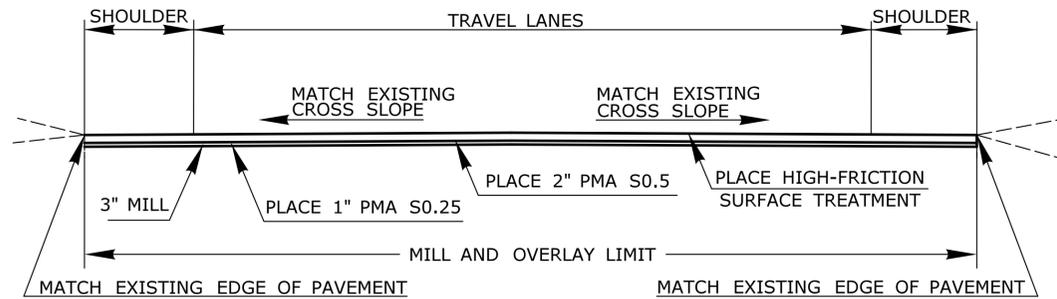


CT ROUTE - 3 NORTHBOUND
ROADWAY TREATMENT FOR MM 13.98 - 14.10 NB ONLY

CONSTRUCTION NOTES:

1. THE CONTRACTOR SHALL INSTALL HIGH-FRICTION SURFACE TREATMENT (HFST) AS SPECIFIED IN THE SPECIAL PROVISIONS (ITEM #0406163A).
2. POTHOLES LESS THAN 2.5" IN DEPTH AND DETERIORATED AREAS LEFT AFTER MILLING SHALL BE REPAIRED AS DETERMINED BY THE ENGINEER UNDER THE ITEM #0406125A. POTHOLES GREATER THAN 2.5" IN DEPTH SHALL BE REPAIRED AS DETERMINED BY THE ENGINEER UNDER THE ITEM #0601192A.
3. RUMBLE STRIPS SHALL BE INSTALLED AT EXISTING LOCATIONS AND AS SPECIFIED IN THE SPECIAL PROVISIONS OR AS DIRECTED BY THE ENGINEER.
4. THE HIGH-FRICTION SURFACE TREATMENT (HFST) SHALL NOT BE GROOVED FOR PAVEMENT PARKING.
5. TEMPORARY PAVEMENT MARKINGS SHALL BE REMOVED BETWEEN PAVING LIFTS.

NOT TO SCALE

TYPICAL CROSS SECTION OF ROADWAY
(TREATMENT IV)

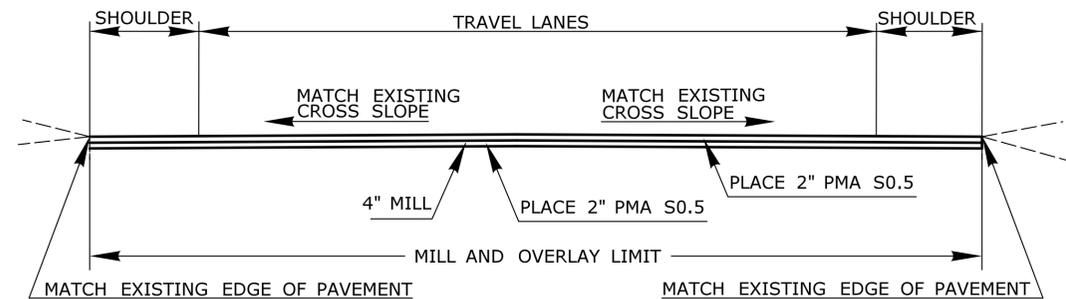

CT ROUTE - 3 SOUTHBOUND
ROADWAY TREATMENT FOR MM 13.67 - 14.10 SB ONLY


CONSTRUCTION NOTES:

1. POTHOLES LESS THAN 2.5" IN DEPTH AND DETERIORATED AREAS LEFT AFTER MILLING SHALL BE REPAIRED AS DETERMINED BY THE ENGINEER UNDER THE ITEM #0406125A. POTHOLES GREATER THAN 2.5" IN DEPTH SHALL BE REPAIRED AS DETERMINED BY THE ENGINEER UNDER THE ITEM #0601192A.
2. RUMBLE STRIPS SHALL BE INSTALLED AT EXISTING LOCATIONS AND AS SPECIFIED IN THE SPECIAL PROVISIONS OR AS DIRECTED BY THE ENGINEER.
3. TEMPORARY PAVEMENT MARKINGS SHALL BE REMOVED BETWEEN PAVING LIFTS.

NOT TO SCALE

REV.	DATE	REVISION DESCRIPTION	SHEET NO.	Plotted Date: 11/24/2015	DESIGNER/DRAFTER: JB	CHECKED BY: SN	SCALE AS NOTED	<p>STATE OF CONNECTICUT DEPARTMENT OF TRANSPORTATION</p>	SIGNATURE/ BLOCK: OFFICE OF ENGINEERING	APPROVED BY: <i>Willie B. [Signature]</i>	PROJECT TITLE: PAVEMENT PRESERVATION OF ROUTE 3	TOWN: WETHERSFIELD GLASTONBURY	PROJECT NO. 159-192
												DRAWING TITLE: TYPICAL SECTIONS	DRAWING NO. HWY-03
													SHEET NO. 03.03

TYPICAL CROSS SECTION OF ROADWAY
(TREATMENT V)

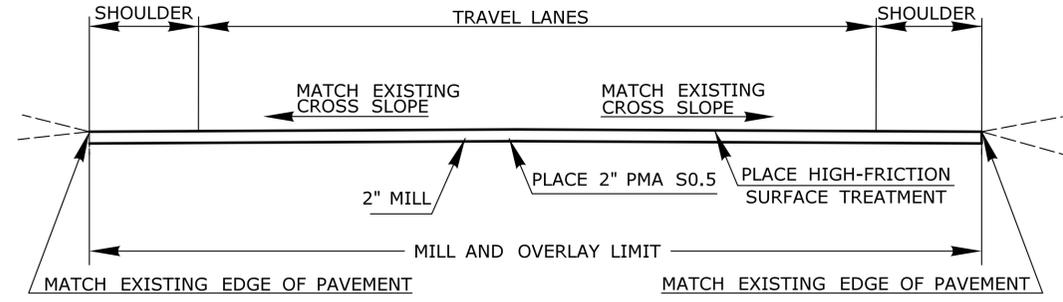

CT ROUTE - 3 NORTHBOUND


RAMP FOR RTE 3 NB TO GLASTONBURY BLVD

CONSTRUCTION NOTES:

1. THE CONTRACTOR SHALL INSTALL HIGH-FRICTION SURFACE TREATMENT (HFST) AS SPECIFIED IN THE SPECIAL PROVISIONS (ITEM #0406163A).
2. PRIOR TO PLACEMENT OF POLYMER MODIFIED ASPHALT, JOINT AND CRACK FILLING OF EXISTING BITUMINOUS PAVEMENT (ITEM #0406195A) SHALL BE PERFORMED.
3. POTHOLES LESS THAN 2.5" IN DEPTH AND DETERIORATED AREAS LEFT AFTER MILLING SHALL BE REPAIRED AS DETERMINED BY THE ENGINEER UNDER THE ITEM #0406125A. POTHOLES GREATER THAN 2.5" IN DEPTH SHALL BE REPAIRED AS DETERMINED BY THE ENGINEER UNDER THE ITEM #0601192A.
4. RUMBLE STRIPS SHALL BE INSTALLED AT EXISTING LOCATIONS AND AS SPECIFIED IN THE SPECIAL PROVISIONS OR AS DIRECTED BY THE ENGINEER.
5. THE HIGH-FRICTION SURFACE TREATMENT (HFST) SHALL NOT BE GROOVED FOR PAVEMENT PARKING.
6. TEMPORARY PAVEMENT MARKINGS SHALL BE REMOVED BETWEEN PAVING LIFTS.

NOT TO SCALE

TEMPORARY TRANSITION DETAIL

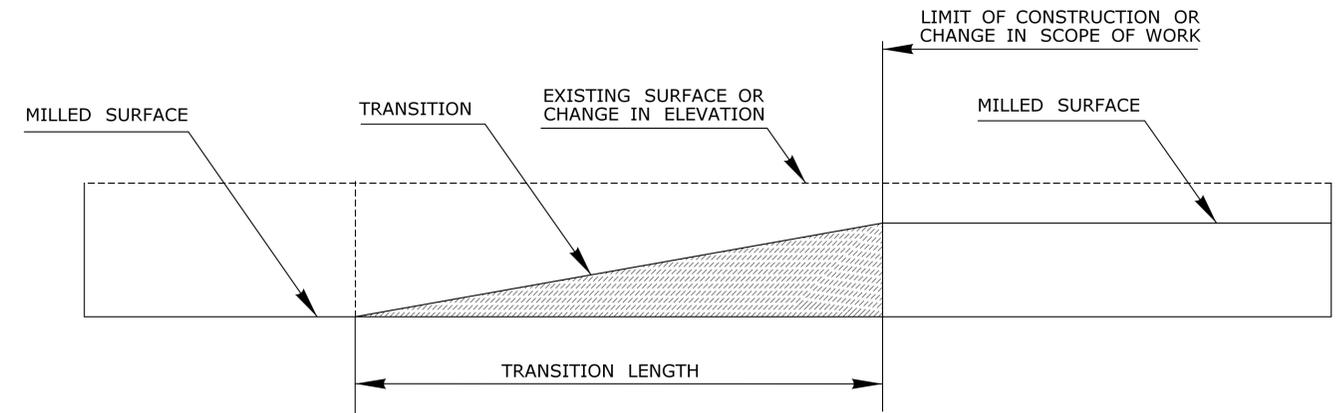


GENERAL NOTES:

1. TEMPORARY TRANSITION SHALL BE PAID FOR UNDER ITEM # 0406275A - FINE MILLING OF BITUMINOUS CONCRETE (0 TO 4").
2. ALL PAVEMENT TRANSITION LENGTHS SHALL CONFORM TO SECTION 04.06 OF THE SPECIAL PROVISIONS.
3. TEMPORARY TRANSITION MUST BE OUTSIDE OF THE 50 FT BUFFER AT BRIDGE LOCATIONS.


NOT TO SCALE

TYPICAL CROSS SECTION OF ROADWAY ON BRIDGES
(TREATMENT VI)

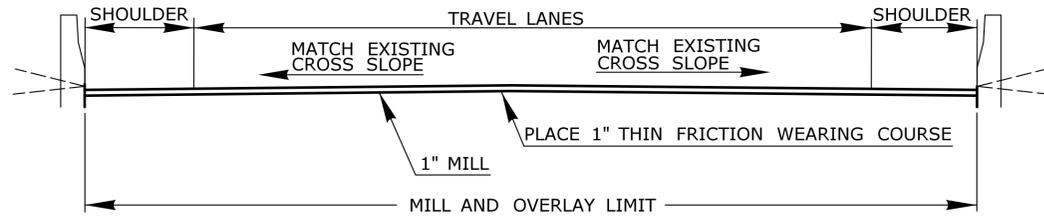

ROUTE 3 BRIDGE SECTIONS

BRIDGE NO. 06288, 06289, 06290, 00419, 05546, 05561, AND 05562

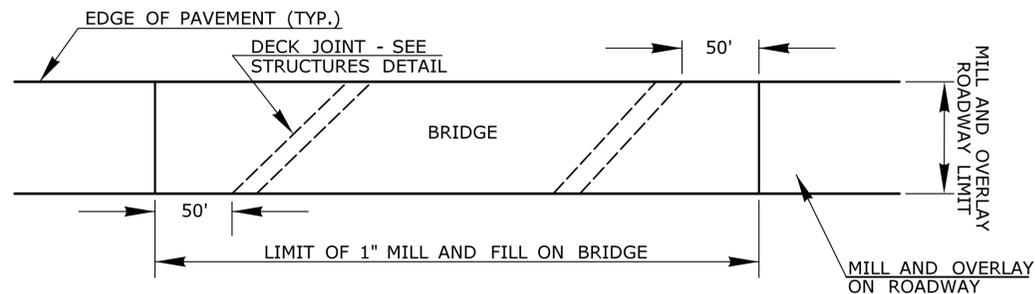

ROUTE 3 BRIDGE PLAN

BRIDGE NO. 06288, 06289, 06290, 00419, 05546, 05561, AND 05562

GENERAL NOTES:

1. THE CONTRACTOR SHALL MILL AND OVERLAY OVER EXISTING BRIDGE JOINTS EXCEPT FOR BOTH JOINTS ON BRIDGE NO. 06289 AND THE MODULAR JOINT ON BRIDGE NO. 06290.
2. SEE SUBSET 04 - STRUCTURE SHEETS FOR PROPOSED BRIDGE WORK.


NOT TO SCALE

TREATMENT TYPE	DESCRIPTION
TREATMENT I	- Mill to a 3" depth using Item #0406275A - Fine Milling of Bituminous Concrete (0 to 4") from EOR-to-EOR. - Place one 2" lift of PMA S0.5 on one 1" lift of PMA S0.25 from EOR-to-EOR.
TREATMENT II	- Mill to a 2" depth using Item #0406275A - Fine Milling of Bituminous Concrete (0 to 4") from EOR-to-EOR. - Place a 2" Lift of PMA S0.5 from EOR-to-EOR.
TREATMENT III	- Mill to a 3" depth using Item #0406275A - Fine Milling of Bituminous Concrete (0 to 4") from EOR-to-EOR. - Place one 2" lift of PMA S0.5 on one 1" lift of PMA S0.25 from EOR-to-EOR. - Place High-Friction Surface Treatment (HFST) using Item #0406163A from EOR-to-EOR.
TREATMENT IV	- Mill to a 4" depth using Item #0406275A - Fine Milling of Bituminous Concrete (0 to 4") from EOR-to-EOR. - Place two 2" lifts of PMA S0.5 from EOR-to-EOR.
TREATMENT V	- Mill to a 2" depth using Item #0406275A - Fine Milling of Bituminous Concrete (0 to 4") from EOR-to-EOR. - Place a 2" Lift of PMA S0.5 from EOR-to-EOR. - Place High-Friction Surface Treatment (HFST) using Item #0406163A from EOR-to-EOR.
TREATMENT VI	- Mill to a 1" depth using Item #0406275A - Fine Milling of Bituminous Concrete (0 to 4") from EOR-to-EOR. - Place a 1" Lift of thin friction wearing course using Item # 0406164 from EOR-to-EOR.

GENERAL NOTES:

1. THE CONTRACTOR SHALL REFER TO THE TYPICAL CROSS SECTIONS AND CONSTRUCTION NOTES ON DRAWING NO. HWY-03 AND HWY-04 FOR TREATMENT DETAILS.
2. THE TABLE IS ONLY A DESCRIPTION OF TREATMENT TYPES AND SHOULD NOT BE USED AS A SEQUENCE OF OPERATIONS.

<table border="1"> <tr> <td>REV.</td> <td>DATE</td> <td>REVISION DESCRIPTION</td> <td>SHEET NO.</td> </tr> <tr> <td>-</td> <td>-</td> <td>-</td> <td>-</td> </tr> </table>	REV.	DATE	REVISION DESCRIPTION	SHEET NO.	-	-	-	-	-	-	-	-	-	-	-	-	-	-	-	-	-	-	-	-	THE INFORMATION, INCLUDING ESTIMATED QUANTITIES OF WORK, SHOWN ON THESE SHEETS IS BASED ON LIMITED INVESTIGATIONS BY THE STATE AND IS IN NO WAY WARRANTED TO INDICATE THE CONDITIONS OF ACTUAL QUANTITIES OF WORK WHICH WILL BE REQUIRED. Plotted Date: 11/30/2015	DESIGNER/DRAFTER: JB CHECKED BY: SN SCALE AS NOTED	STATE OF CONNECTICUT DEPARTMENT OF TRANSPORTATION Filename: ...VHW_MSH_0159_0192_TYP-02.dgn	SIGNATURE/BLOCK: OFFICE OF ENGINEERING APPROVED BY: <i>Willie B. Butler</i>	PROJECT TITLE: PAVEMENT PRESERVATION OF ROUTE 3	TOWN: WETHERSFIELD GLASTONBURY DRAWING TITLE: TYPICAL SECTIONS	PROJECT NO.: 159-192 DRAWING NO.: HWY-04 SHEET NO.: 03.04
REV.	DATE	REVISION DESCRIPTION	SHEET NO.																												
-	-	-	-																												
-	-	-	-																												
-	-	-	-																												
-	-	-	-																												
-	-	-	-																												

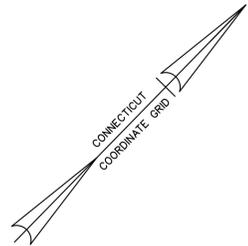

**BEGINNING OF STATE PROJECT NO. 0159-0192
APPROXIMATE MILE MARKER 10.38
LIMIT OF CONSTRUCTION**

**Mill & Overlay
(MM 10.38 - 11.63; and
NB 12.28 - 14.10 &
SB 12.27 - 14.10 incl. ramps
exclusive of I-91 ramps)**


APPROXIMATE FEMA 500-YEAR FLOOD LINE

APPROXIMATE FEMA 100-YEAR FLOOD LINE

LIMIT OF CONSTRUCTION

LIMIT OF CONSTRUCTION

TREATMENT I

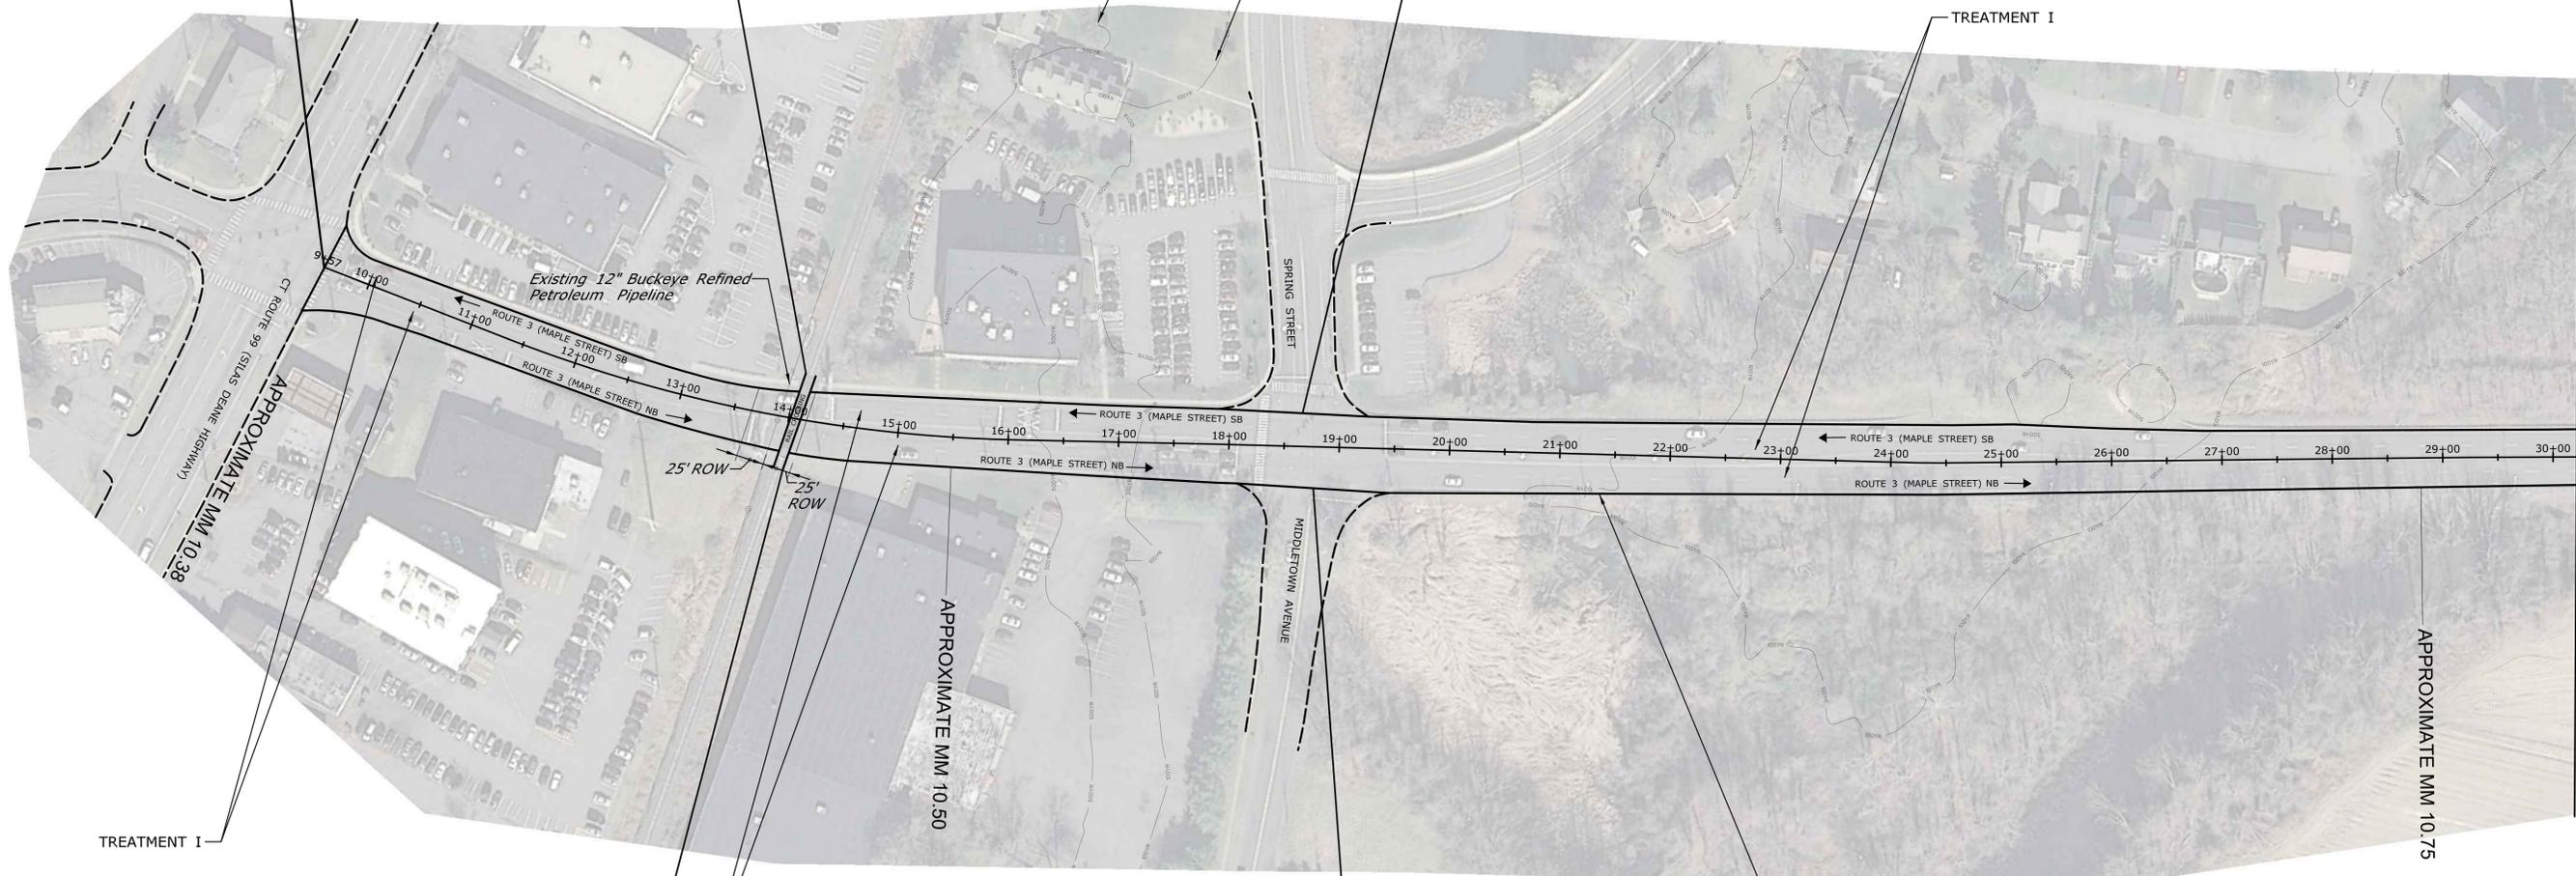

MATCH MARK PLN-02

LIMIT OF CONSTRUCTION

LIMIT OF CONSTRUCTION


BRIDGE NO. 06822

REV.	DATE	REVISION DESCRIPTION	SHEET NO.

THE INFORMATION, INCLUDING ESTIMATED QUANTITIES OF WORK, SHOWN ON THESE SHEETS IS BASED ON LIMITED INVESTIGATIONS BY THE STATE AND IS IN NO WAY WARRANTED TO INDICATE THE CONDITIONS OF ACTUAL QUANTITIES OF WORK WHICH WILL BE REQUIRED.

Plotted Date: 11/25/2015

DESIGNER/DRAFTER: JB
CHECKED BY: SN
SCALE IN FEET
0 80 160
SCALE 1"=80'

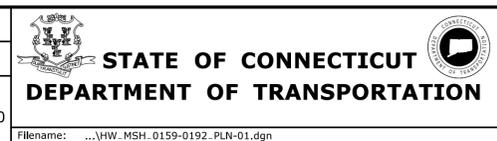


SIGNATURE/BLOCK:
OFFICE OF ENGINEERING
APPROVED BY:
William B. ...

PROJECT TITLE:
**PAVEMENT PRESERVATION
OF ROUTE 3**

TOWN:
**WETHERSFIELD
GLASTONBURY**
DRAWING TITLE:
HIGHWAY PLAN

PROJECT NO.
159-192
DRAWING NO.
PLN-01
SHEET NO.
03.05

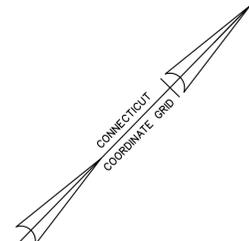

CHANGE IN TREATMENT TYPE
TREATMENT I ← TREATMENT II


LIMIT OF CONSTRUCTION

APPROXIMATE FEMA 100-YEAR FLOOD LINE

TREATMENT II

MATCH MARK PLN-03

MATCH MARK PLN-01

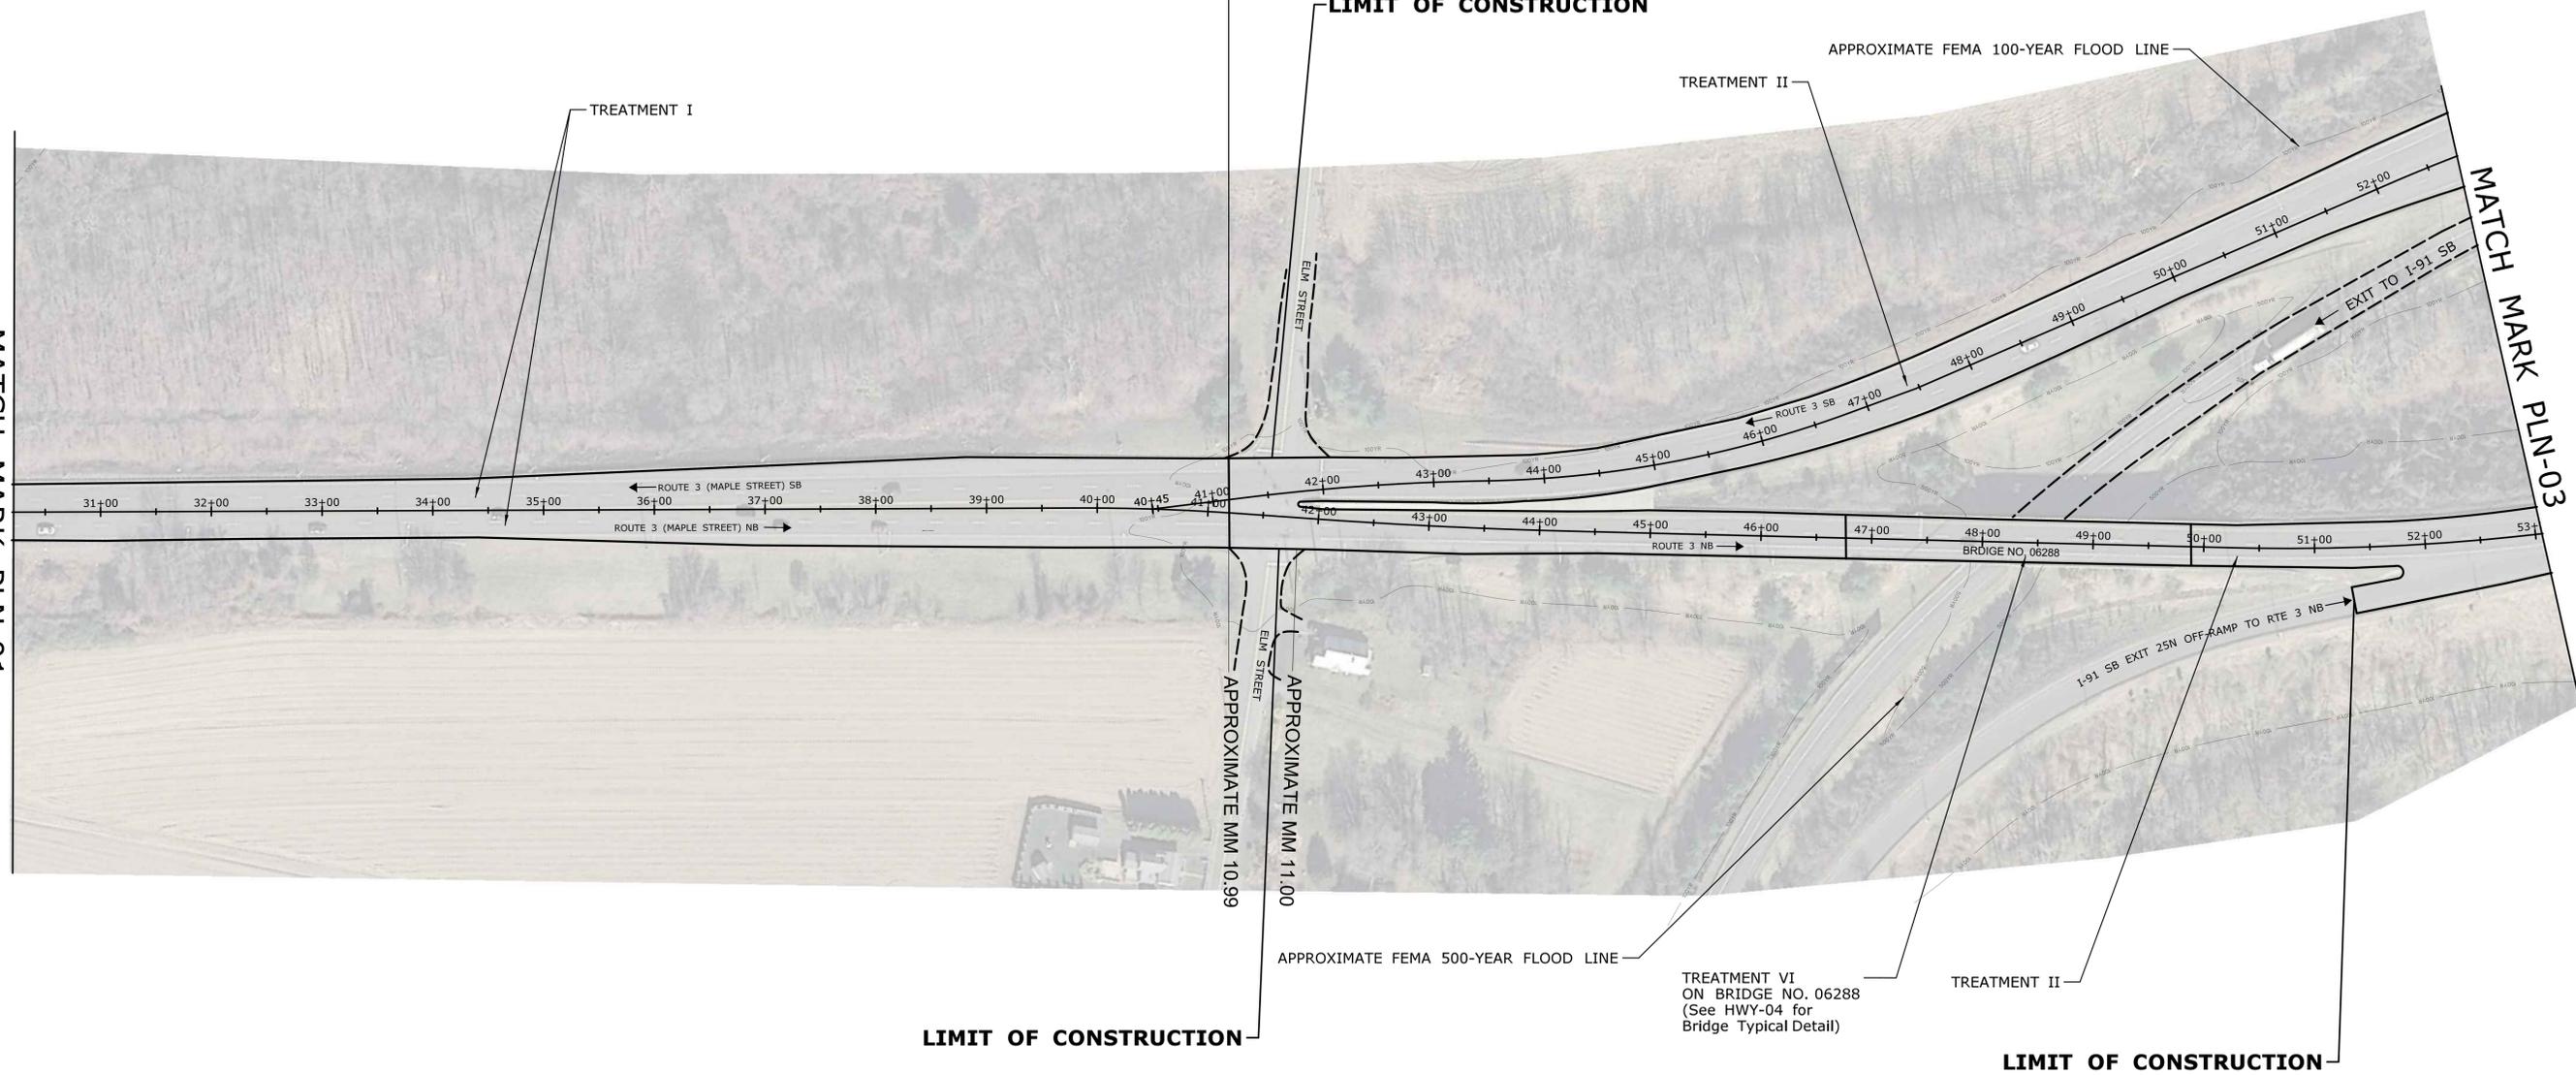

LIMIT OF CONSTRUCTION


LIMIT OF CONSTRUCTION

REV.	DATE	REVISION DESCRIPTION	SHEET NO.

THE INFORMATION, INCLUDING ESTIMATED QUANTITIES OF WORK, SHOWN ON THESE SHEETS IS BASED ON LIMITED INVESTIGATIONS BY THE STATE AND IS IN NO WAY WARRANTED TO INDICATE THE CONDITIONS OF ACTUAL QUANTITIES OF WORK WHICH WILL BE REQUIRED.

Plotted Date: 11/25/2015

DESIGNER/DRAFTER: JB
CHECKED BY: SN
SCALE IN FEET
0 80 160
SCALE 1"=80'


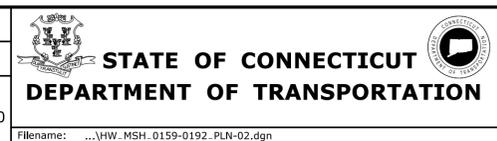


SIGNATURE/BLOCK:
OFFICE OF ENGINEERING
APPROVED BY:
William B. ...

PROJECT TITLE:
PAVEMENT PRESERVATION OF ROUTE 3

TOWN: **WETHERSFIELD GLASTONBURY**
DRAWING TITLE:
HIGHWAY PLAN

PROJECT NO.: **159-192**
DRAWING NO.: **PLN-02**
SHEET NO.: **03.06**

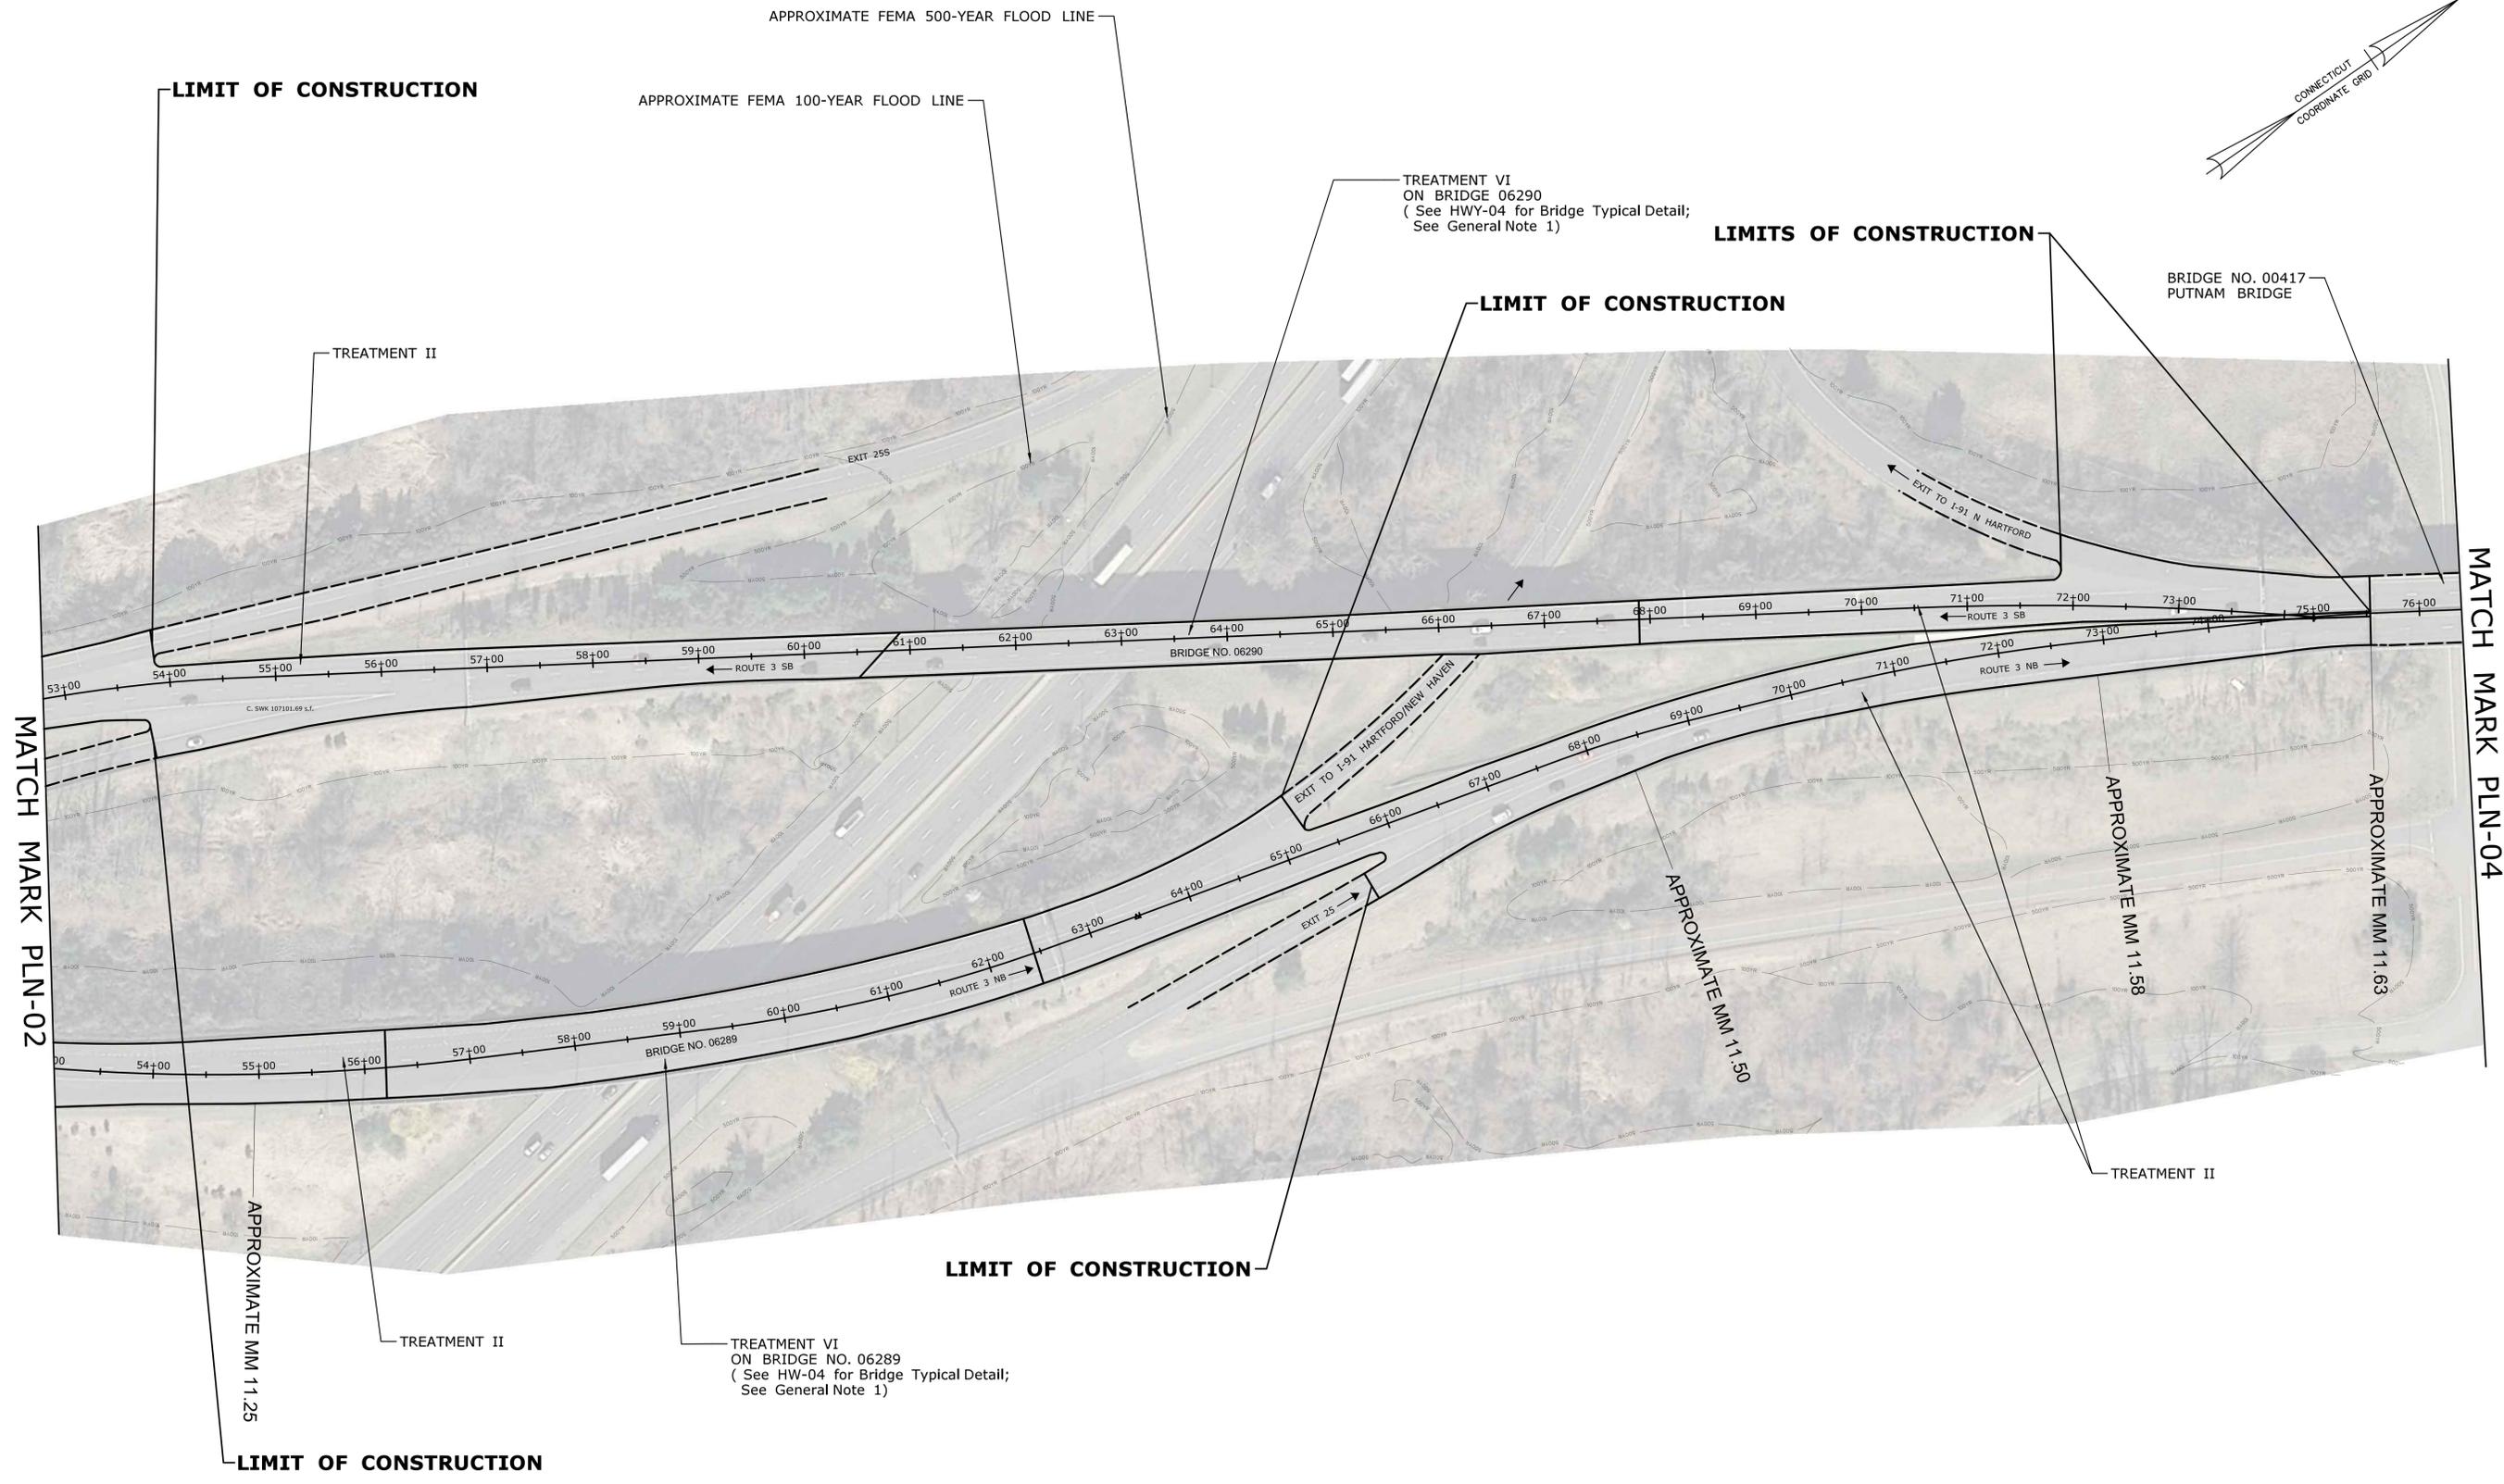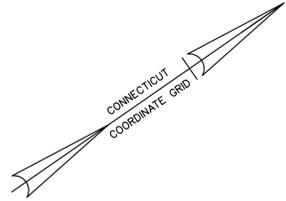

REV.	DATE	REVISION DESCRIPTION	SHEET NO.


THE INFORMATION, INCLUDING ESTIMATED QUANTITIES OF WORK, SHOWN ON THESE SHEETS IS BASED ON LIMITED INVESTIGATIONS BY THE STATE AND IS IN NO WAY WARRANTED TO INDICATE THE CONDITIONS OF ACTUAL QUANTITIES OF WORK WHICH WILL BE REQUIRED.

Plotted Date: 12/1/2015

DESIGNER/DRAFTER:
JB

CHECKED BY:
SN

SCALE IN FEET
0 80 160
SCALE 1"=80'

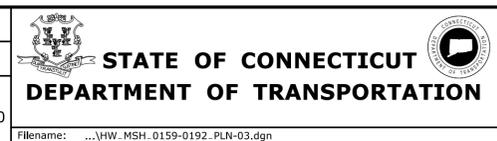

SIGNATURE/
BLOCK:
OFFICE OF ENGINEERING

APPROVED BY:
Willie B. Butler

PROJECT TITLE:
**PAVEMENT PRESERVATION
OF ROUTE 3**


TOWN:
**WETHERSFIELD
GLASTONBURY**

DRAWING TITLE:
HIGHWAY PLAN

PROJECT NO.
159-192

DRAWING NO.
PLN-03

SHEET NO.
03.07

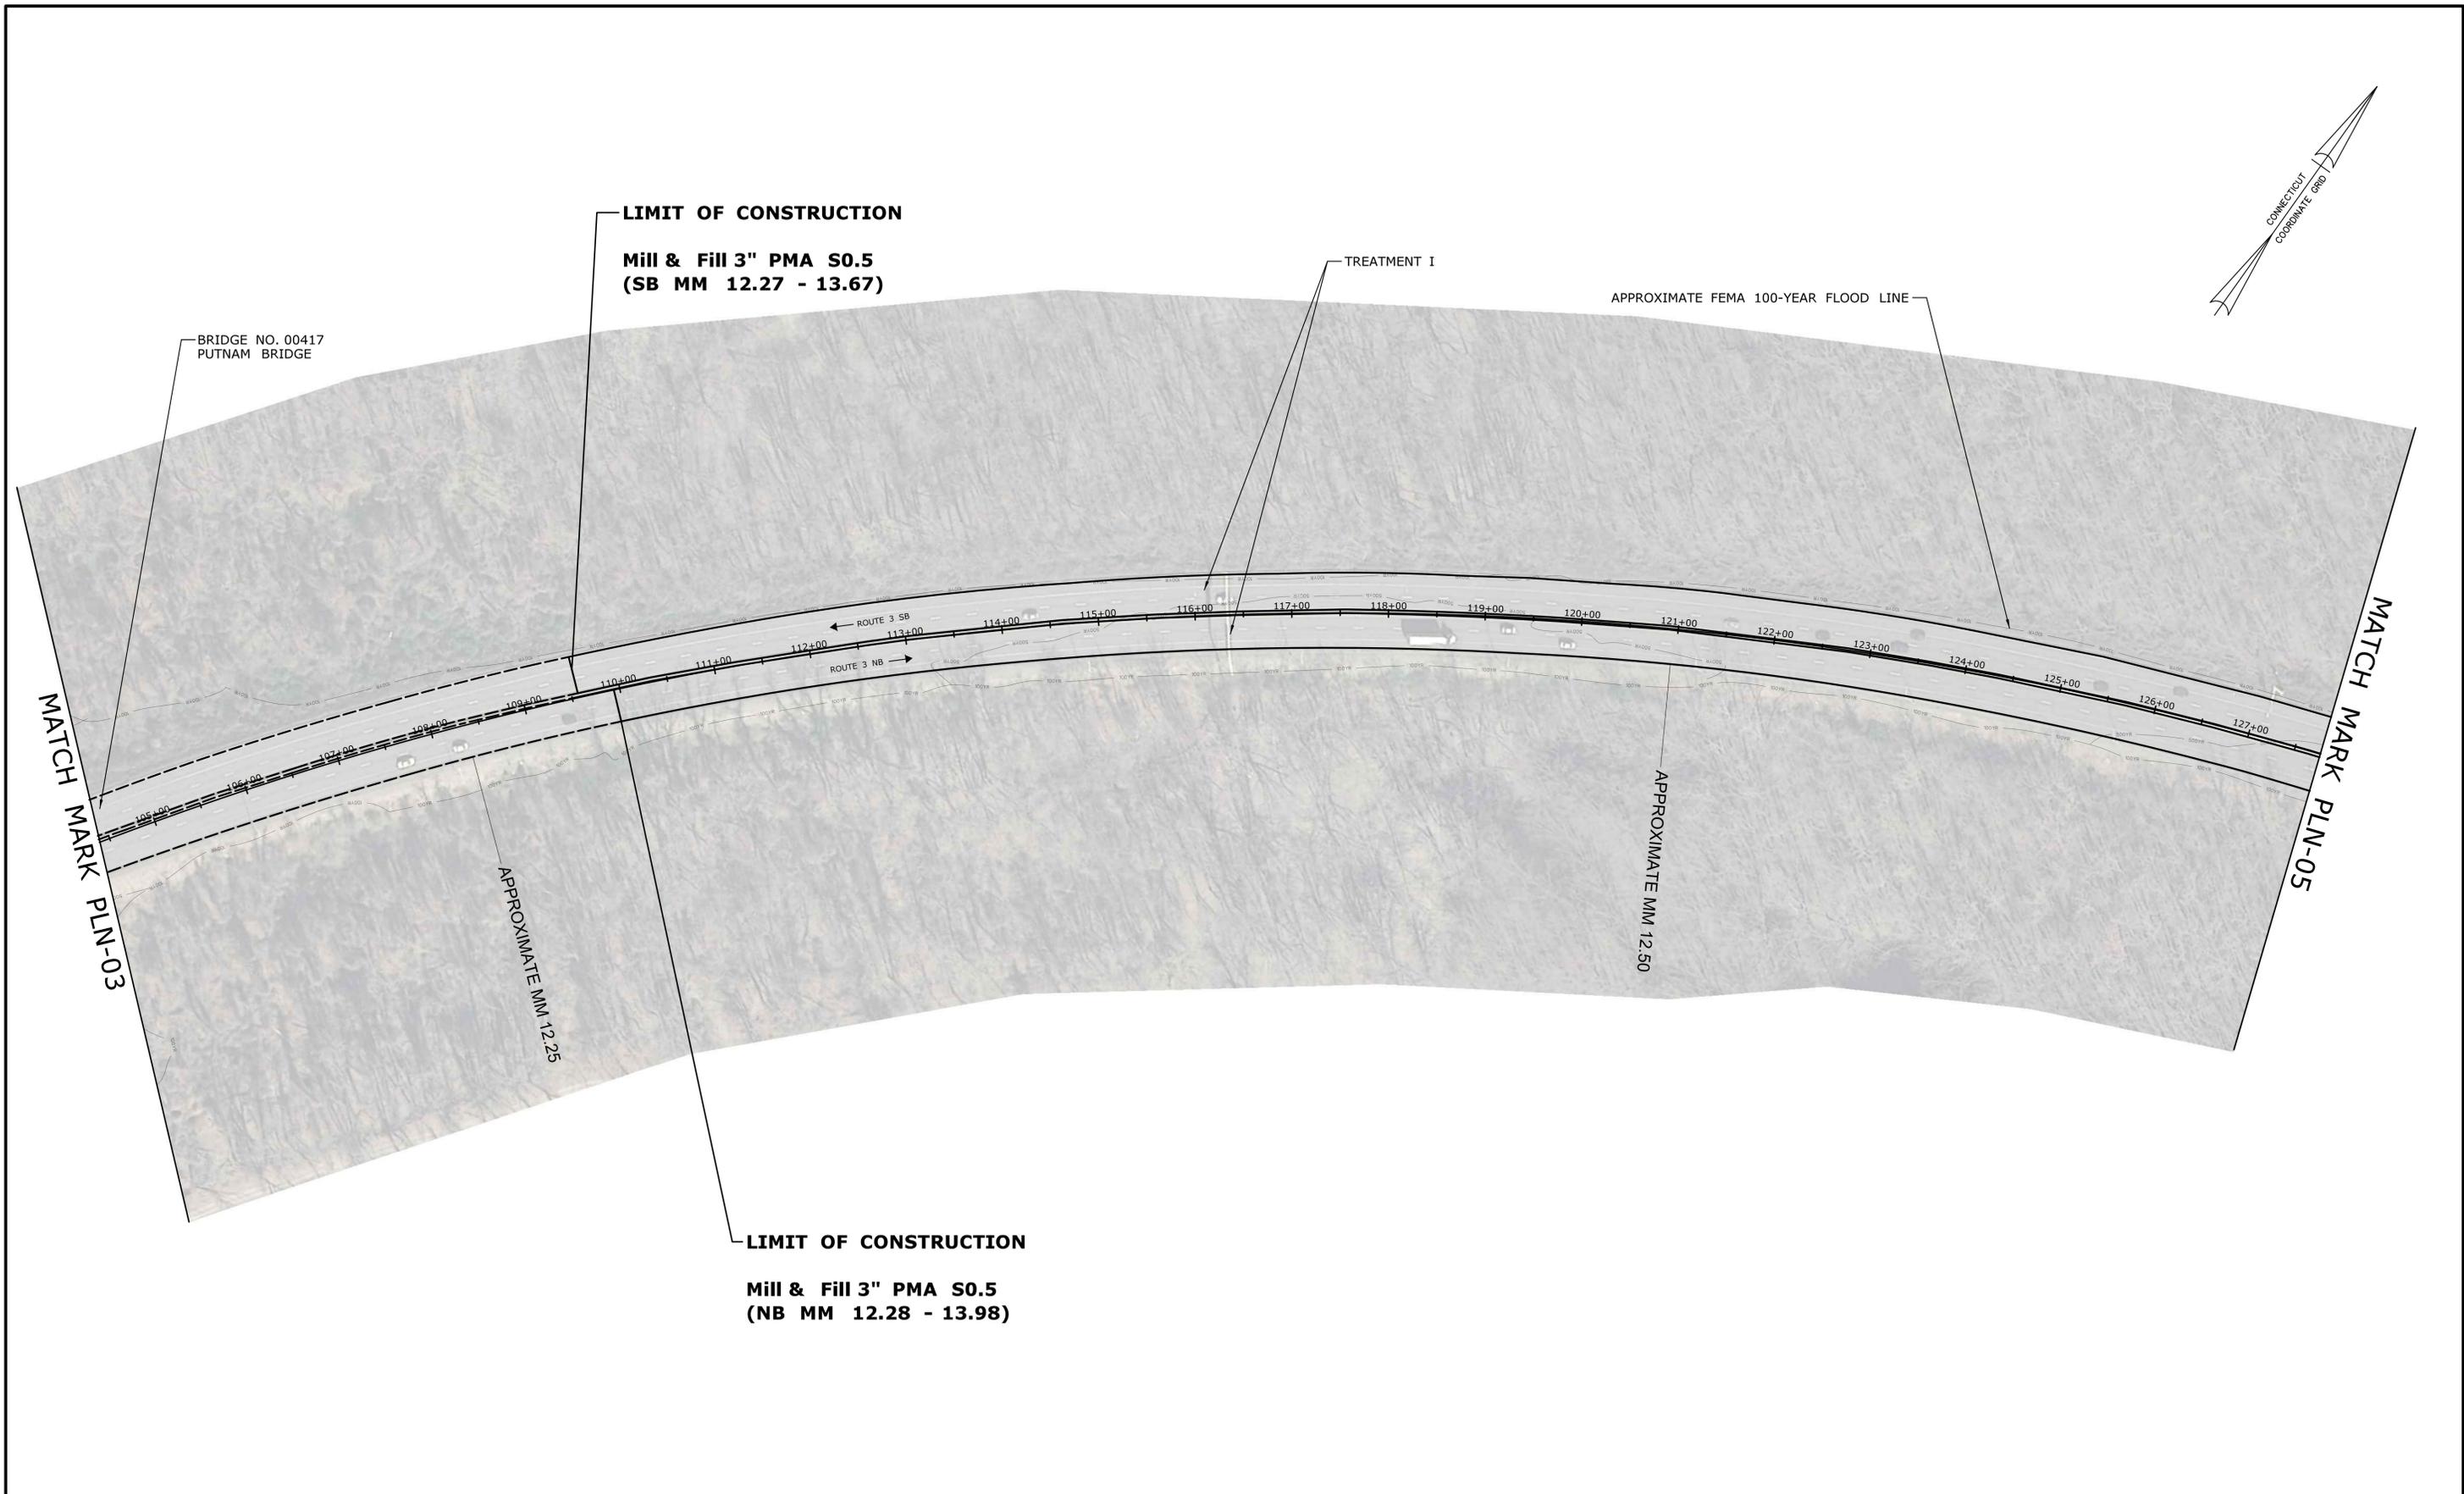

REV.	DATE	REVISION DESCRIPTION	SHEET NO.


THE INFORMATION, INCLUDING ESTIMATED QUANTITIES OF WORK, SHOWN ON THESE SHEETS IS BASED ON LIMITED INVESTIGATIONS BY THE STATE AND IS IN NO WAY WARRANTED TO INDICATE THE CONDITIONS OF ACTUAL QUANTITIES OF WORK WHICH WILL BE REQUIRED.

Plotted Date: 11/25/2015

DESIGNER/DRAFTER:
JB

CHECKED BY:
SN

SCALE IN FEET
0 80 160
SCALE 1"=80'

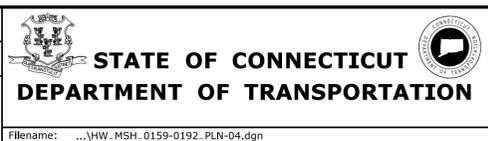

SIGNATURE/
BLOCK:
OFFICE OF ENGINEERING

APPROVED BY:
Willie B. ...

PROJECT TITLE:
**PAVEMENT PRESERVATION
OF ROUTE 3**


TOWN:
**WETHERSFIELD
GLASTONBURY**

DRAWING TITLE:
HIGHWAY PLAN

PROJECT NO.
159-192

DRAWING NO.
PLN-04

SHEET NO.
03.08

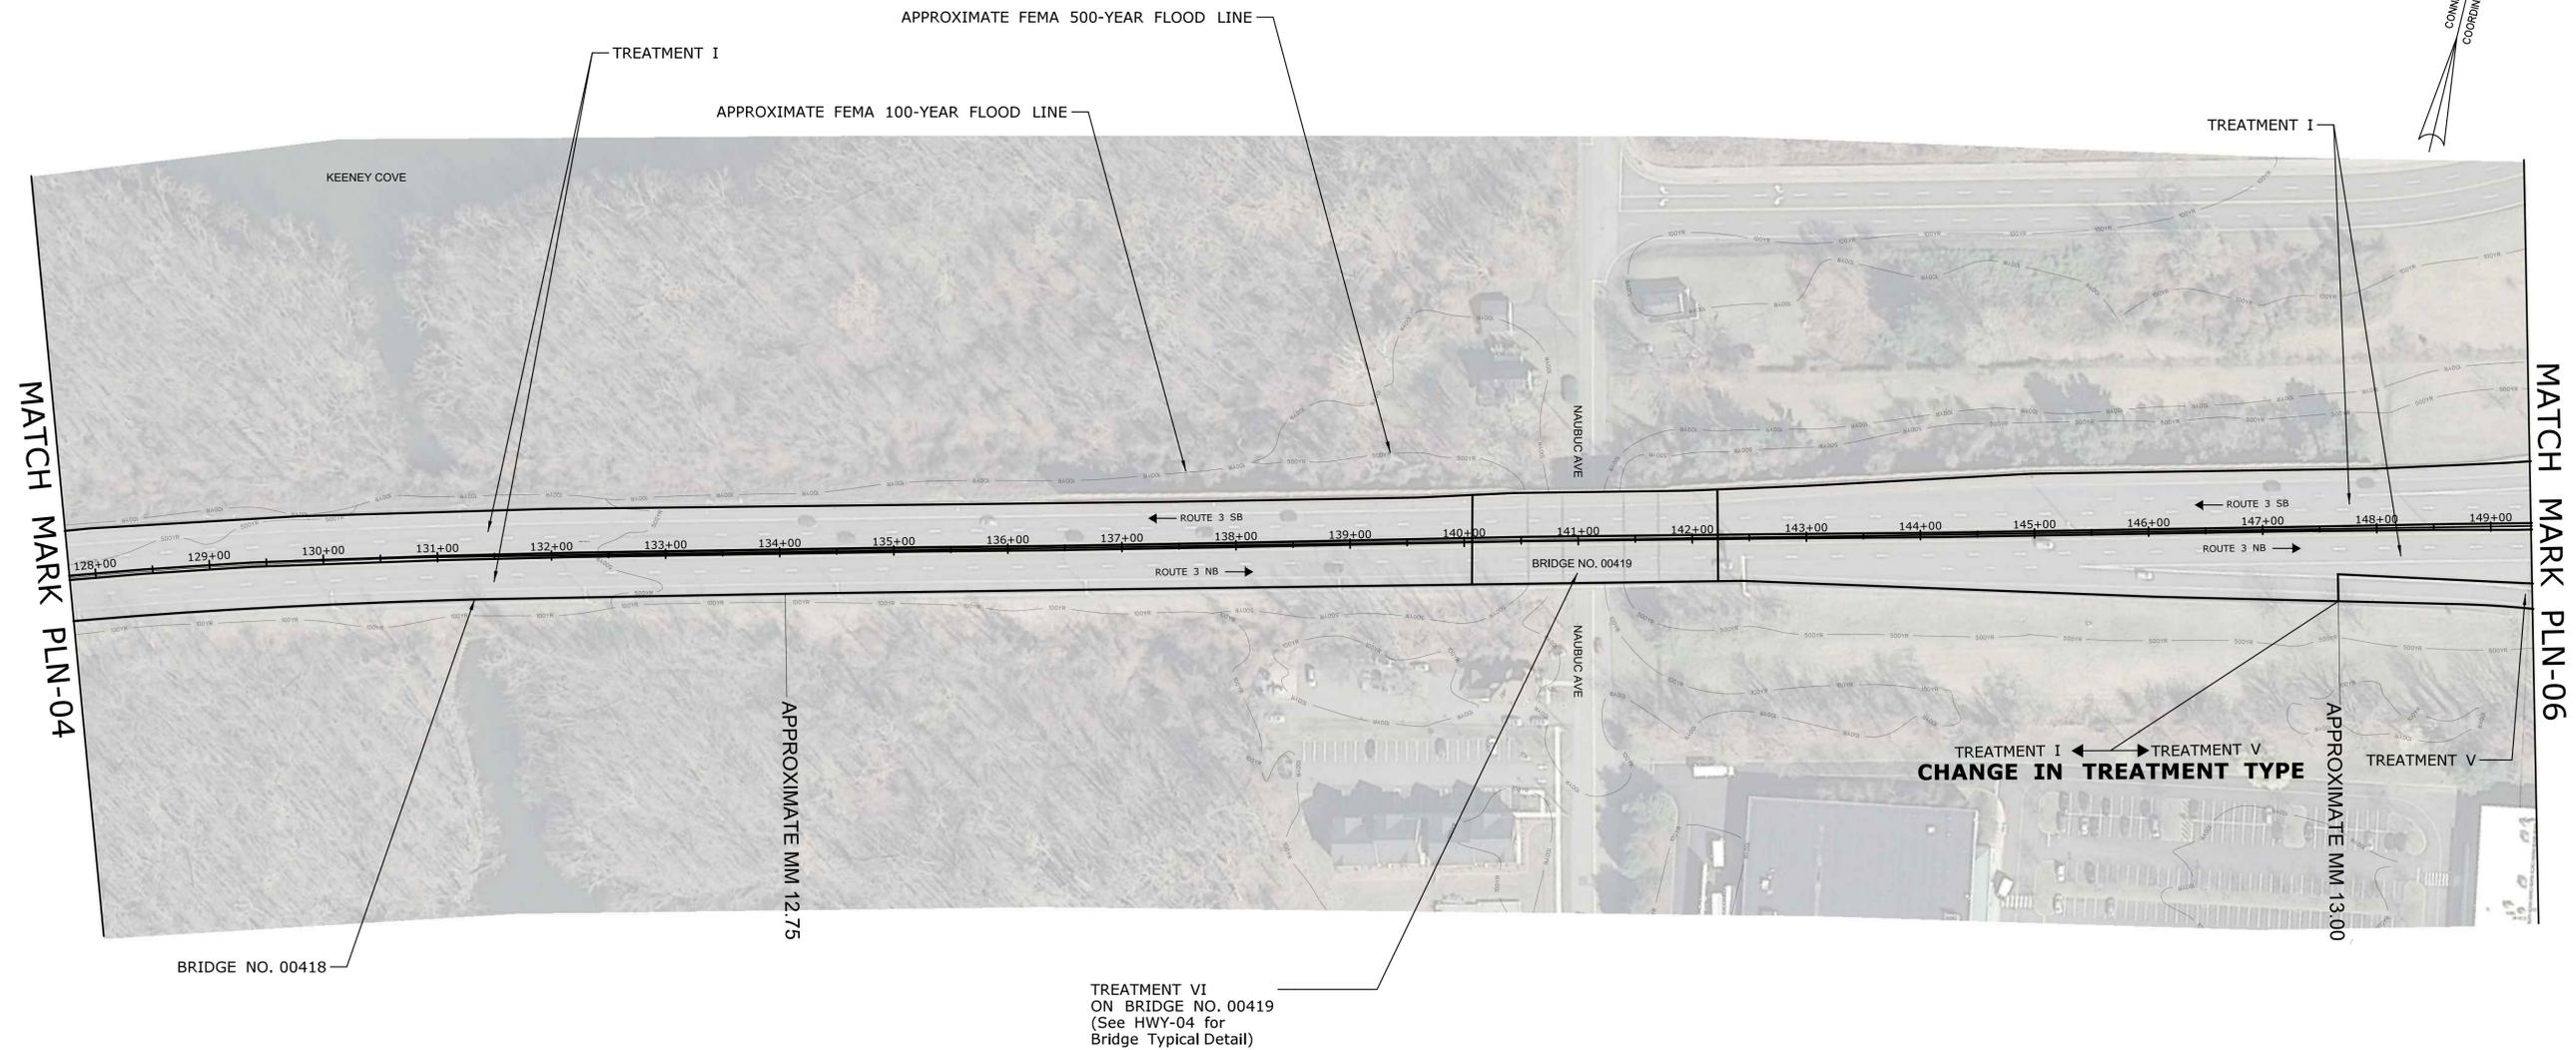


REV.	DATE	REVISION DESCRIPTION	SHEET NO.

THE INFORMATION, INCLUDING ESTIMATED QUANTITIES OF WORK, SHOWN ON THESE SHEETS IS BASED ON LIMITED INVESTIGATIONS BY THE STATE AND IS IN NO WAY WARRANTED TO INDICATE THE CONDITIONS OF ACTUAL QUANTITIES OF WORK WHICH WILL BE REQUIRED.

Plotted Date: 11/25/2015

DESIGNER/DRAFTER: JB
 CHECKED BY: SN
 SCALE IN FEET
 0 80 160
 SCALE 1"=80'

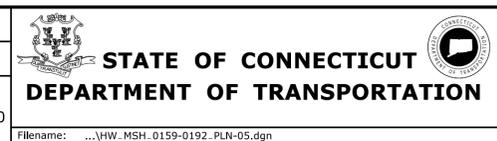


SIGNATURE/BLOCK:
 OFFICE OF ENGINEERING
 APPROVED BY:
Willie B. Butler

PROJECT TITLE:
PAVEMENT PRESERVATION OF ROUTE 3

TOWN: **WETHERSFIELD GLASTONBURY**
 DRAWING TITLE:
HIGHWAY PLAN

PROJECT NO. **159-192**
 DRAWING NO. **PLN-05**
 SHEET NO. **03.09**

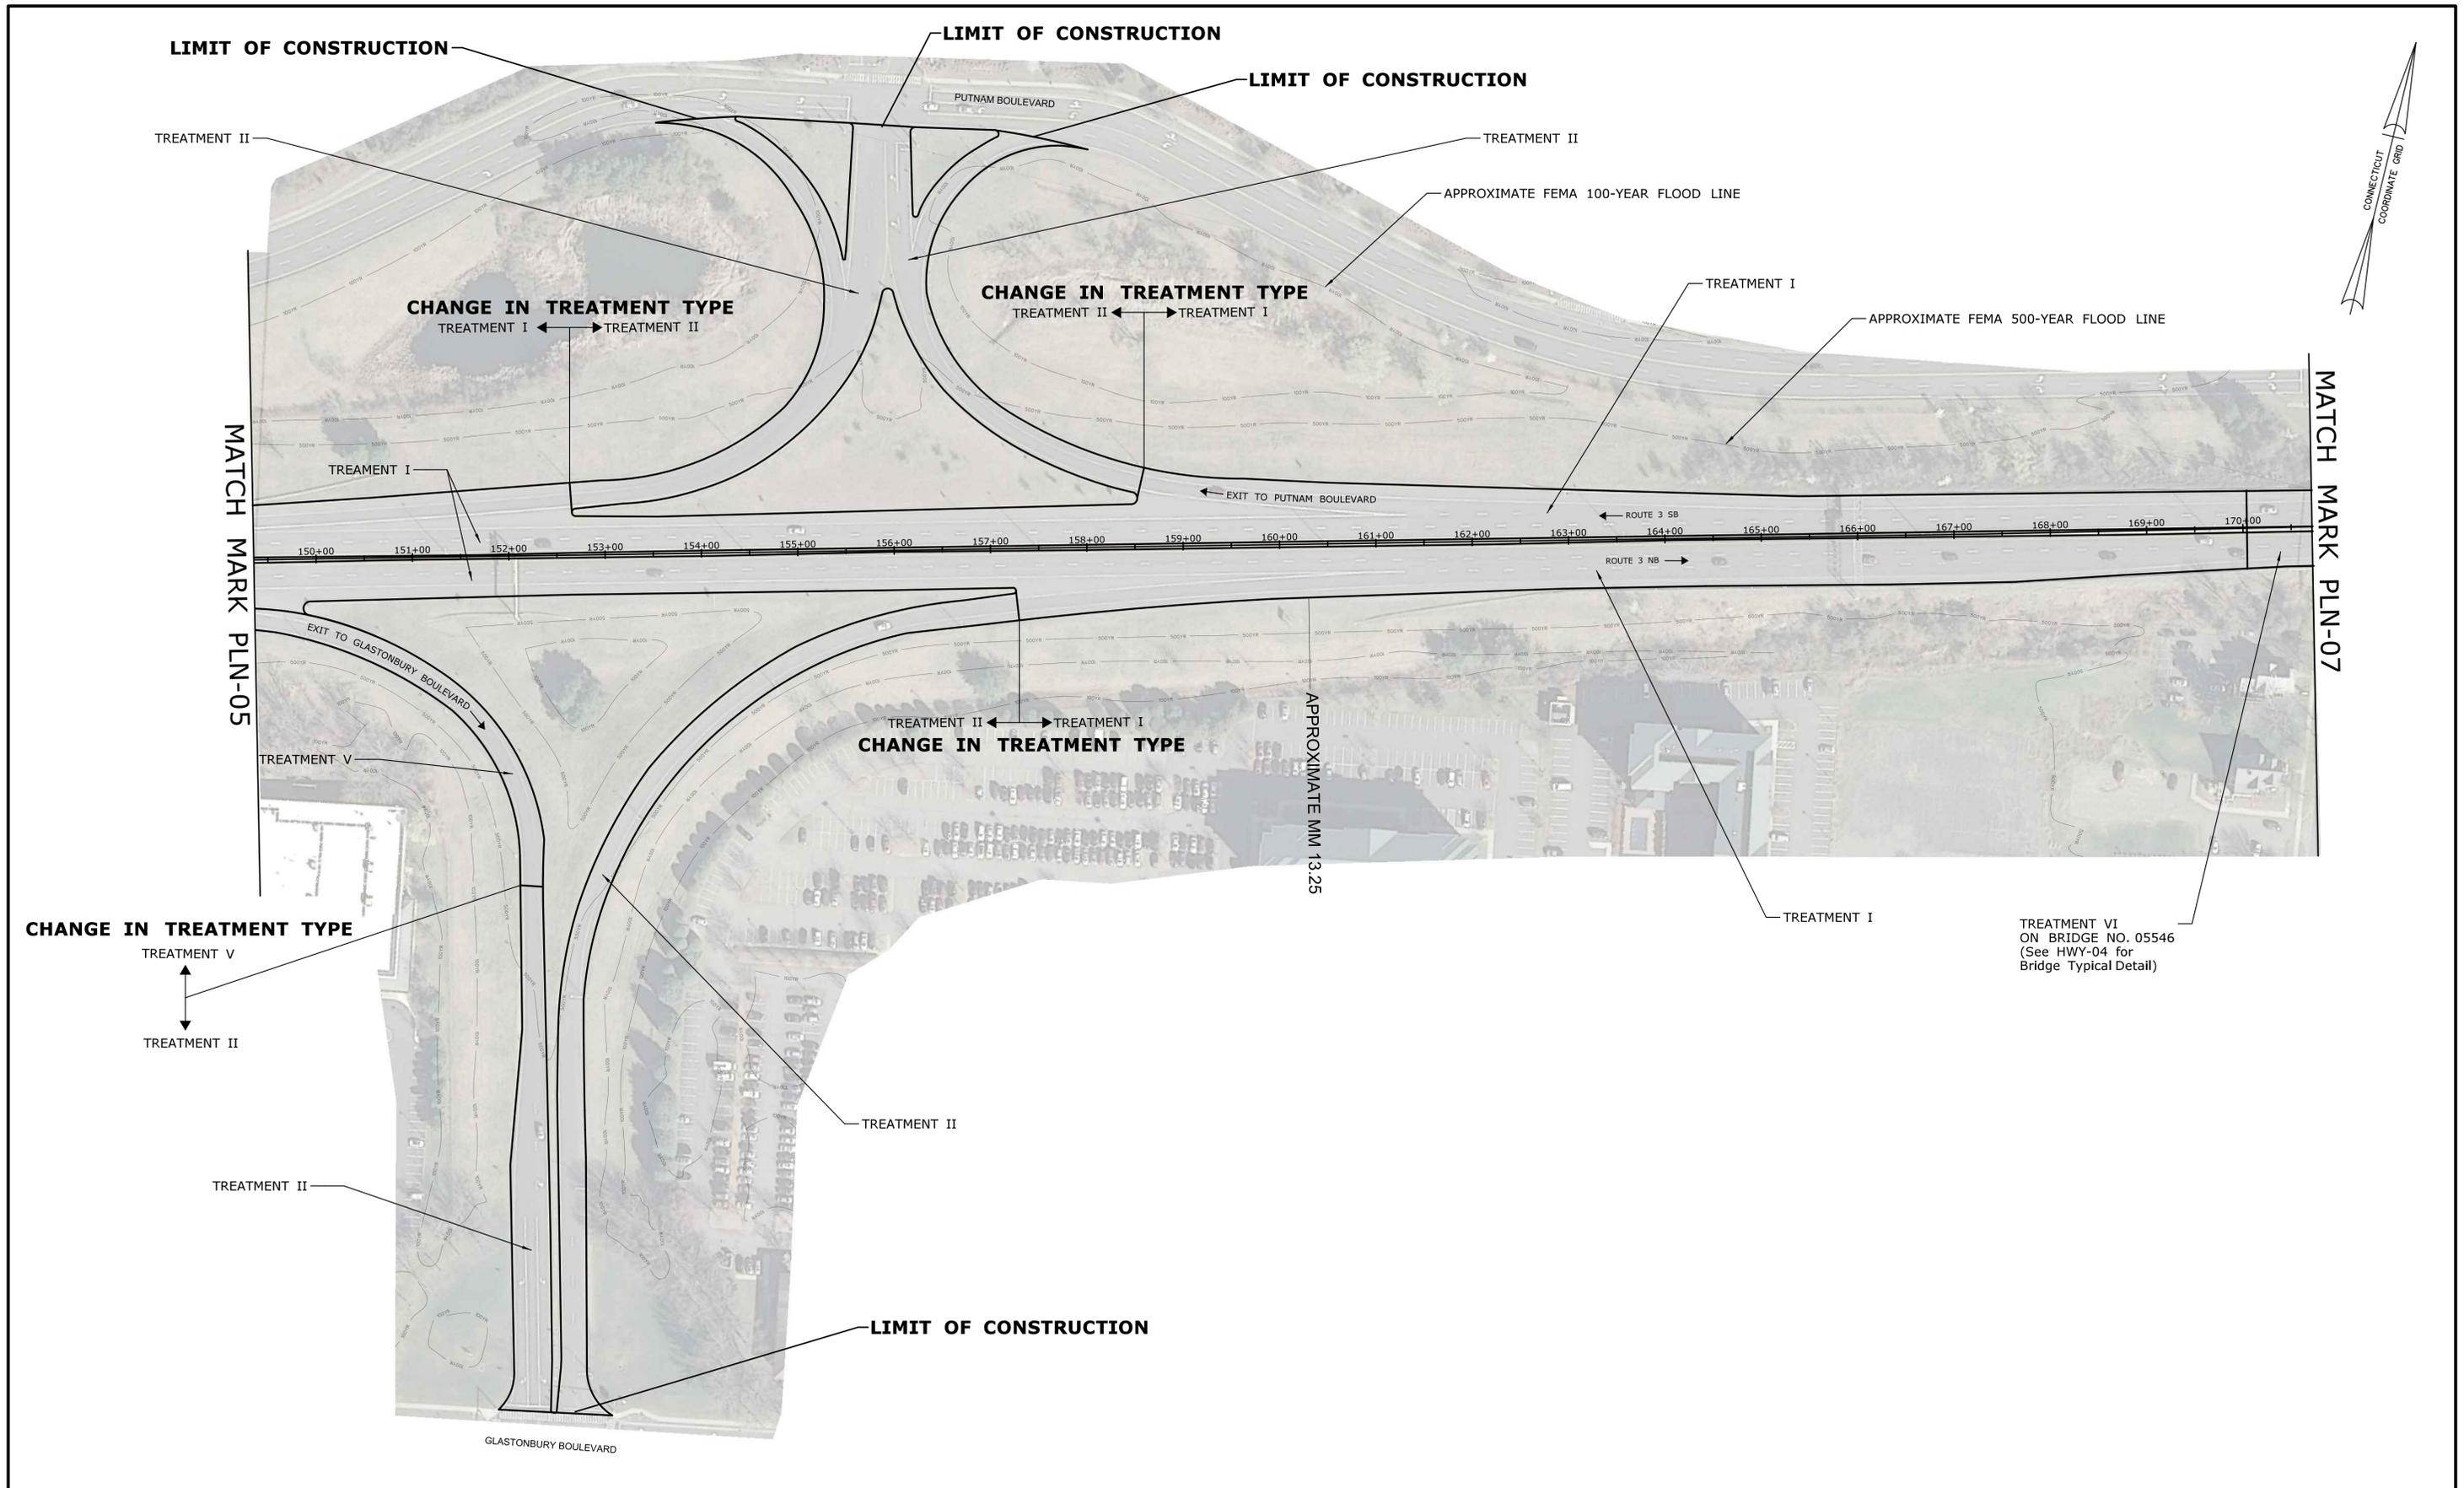

REV.	DATE	REVISION DESCRIPTION	SHEET NO.


THE INFORMATION, INCLUDING ESTIMATED QUANTITIES OF WORK, SHOWN ON THESE SHEETS IS BASED ON LIMITED INVESTIGATIONS BY THE STATE AND IS IN NO WAY WARRANTED TO INDICATE THE CONDITIONS OF ACTUAL QUANTITIES OF WORK WHICH WILL BE REQUIRED.

Plotted Date: 11/25/2015

DESIGNER/DRAFTER:
JB

CHECKED BY:
SN

SCALE IN FEET
0 80 160
SCALE 1"=80'

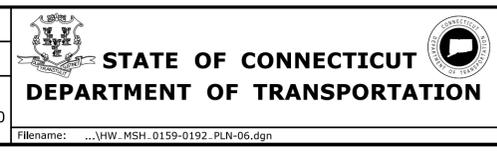

SIGNATURE/
BLOCK:
OFFICE OF ENGINEERING

APPROVED BY:
William B. ...

PROJECT TITLE:
**PAVEMENT PRESERVATION
OF ROUTE 3**


TOWN:
**WETHERSFIELD
GLASTONBURY**

DRAWING TITLE:
HIGHWAY PLAN

PROJECT NO.
159-192

DRAWING NO.
PLN-06

SHEET NO.
03.10

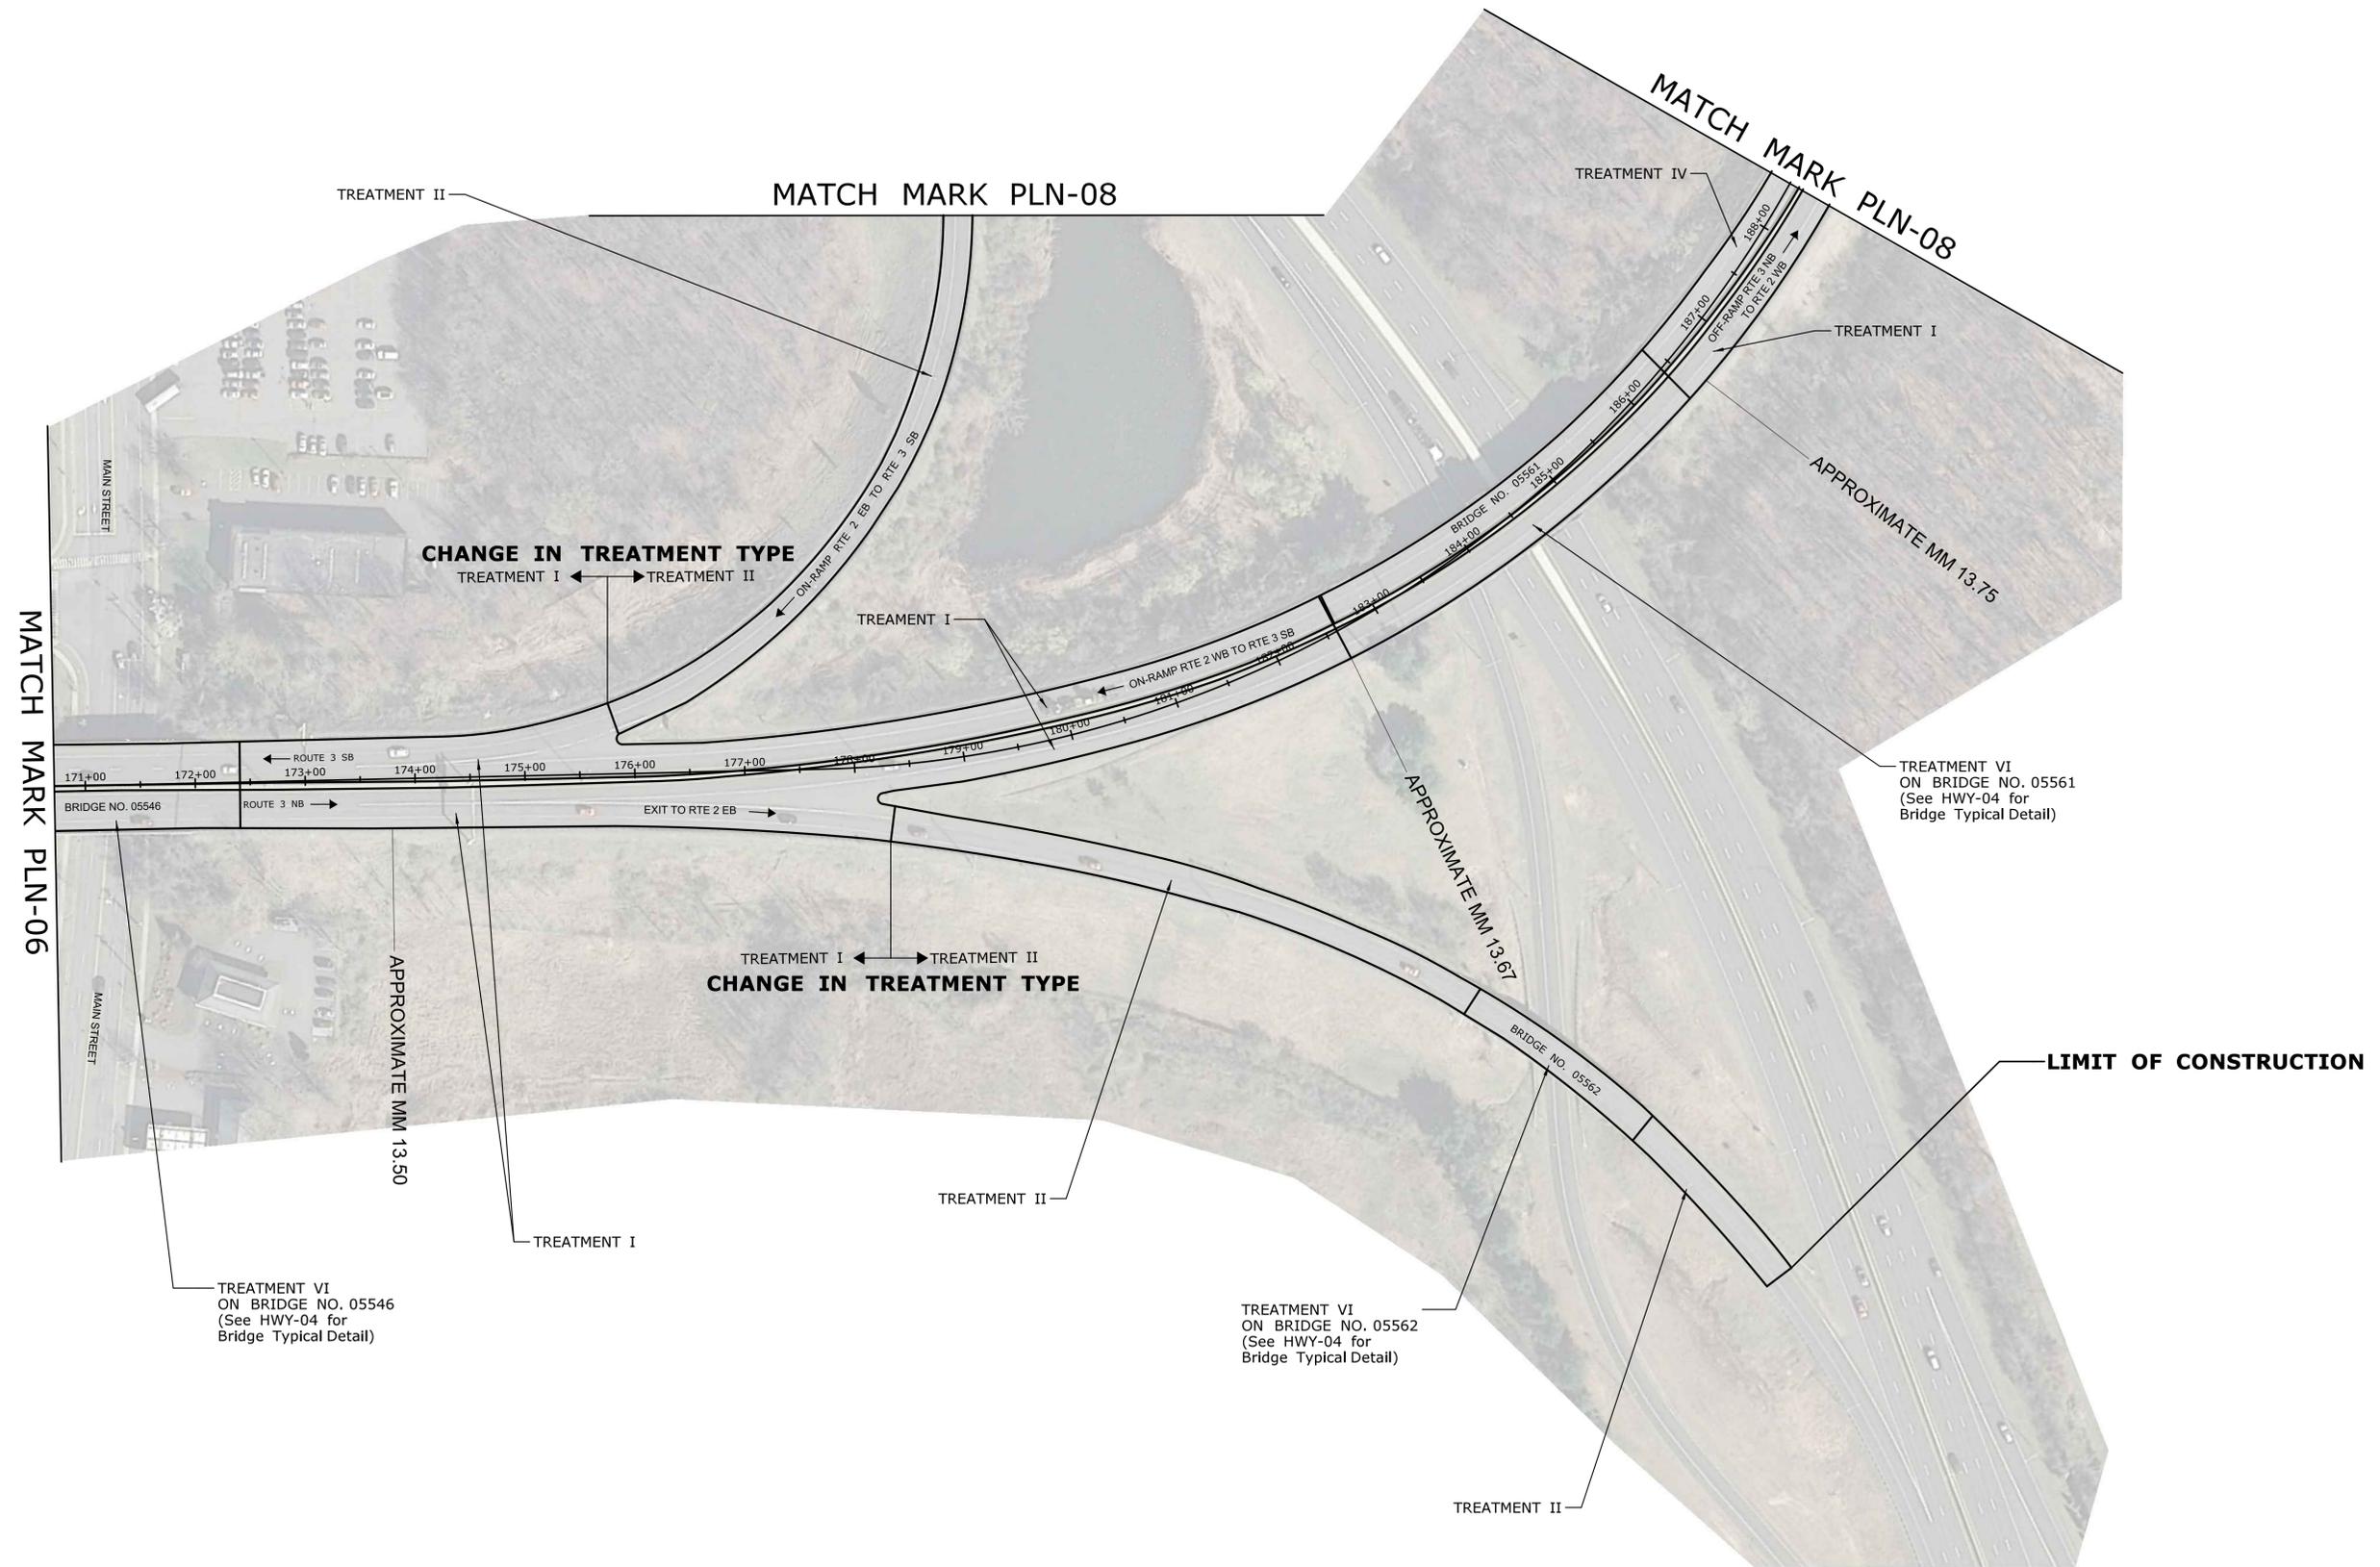

REV.	DATE	REVISION DESCRIPTION	SHEET NO.


THE INFORMATION, INCLUDING ESTIMATED QUANTITIES OF WORK, SHOWN ON THESE SHEETS IS BASED ON LIMITED INVESTIGATIONS BY THE STATE AND IS IN NO WAY WARRANTED TO INDICATE THE CONDITIONS OF ACTUAL QUANTITIES OF WORK WHICH WILL BE REQUIRED.

Plotted Date: 11/25/2015

DESIGNER/DRAFTER:
JB

CHECKED BY:
SN

SCALE IN FEET
0 80 160
SCALE 1"=80'

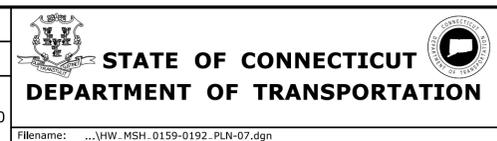

SIGNATURE/
BLOCK:
OFFICE OF ENGINEERING

APPROVED BY:
William B. ...

PROJECT TITLE:
**PAVEMENT PRESERVATION
OF ROUTE 3**


TOWN:
**WETHERSFIELD
GLASTONBURY**

DRAWING TITLE:
HIGHWAY PLAN

PROJECT NO.
159-192

DRAWING NO.
PLN-07

SHEET NO.
03.11

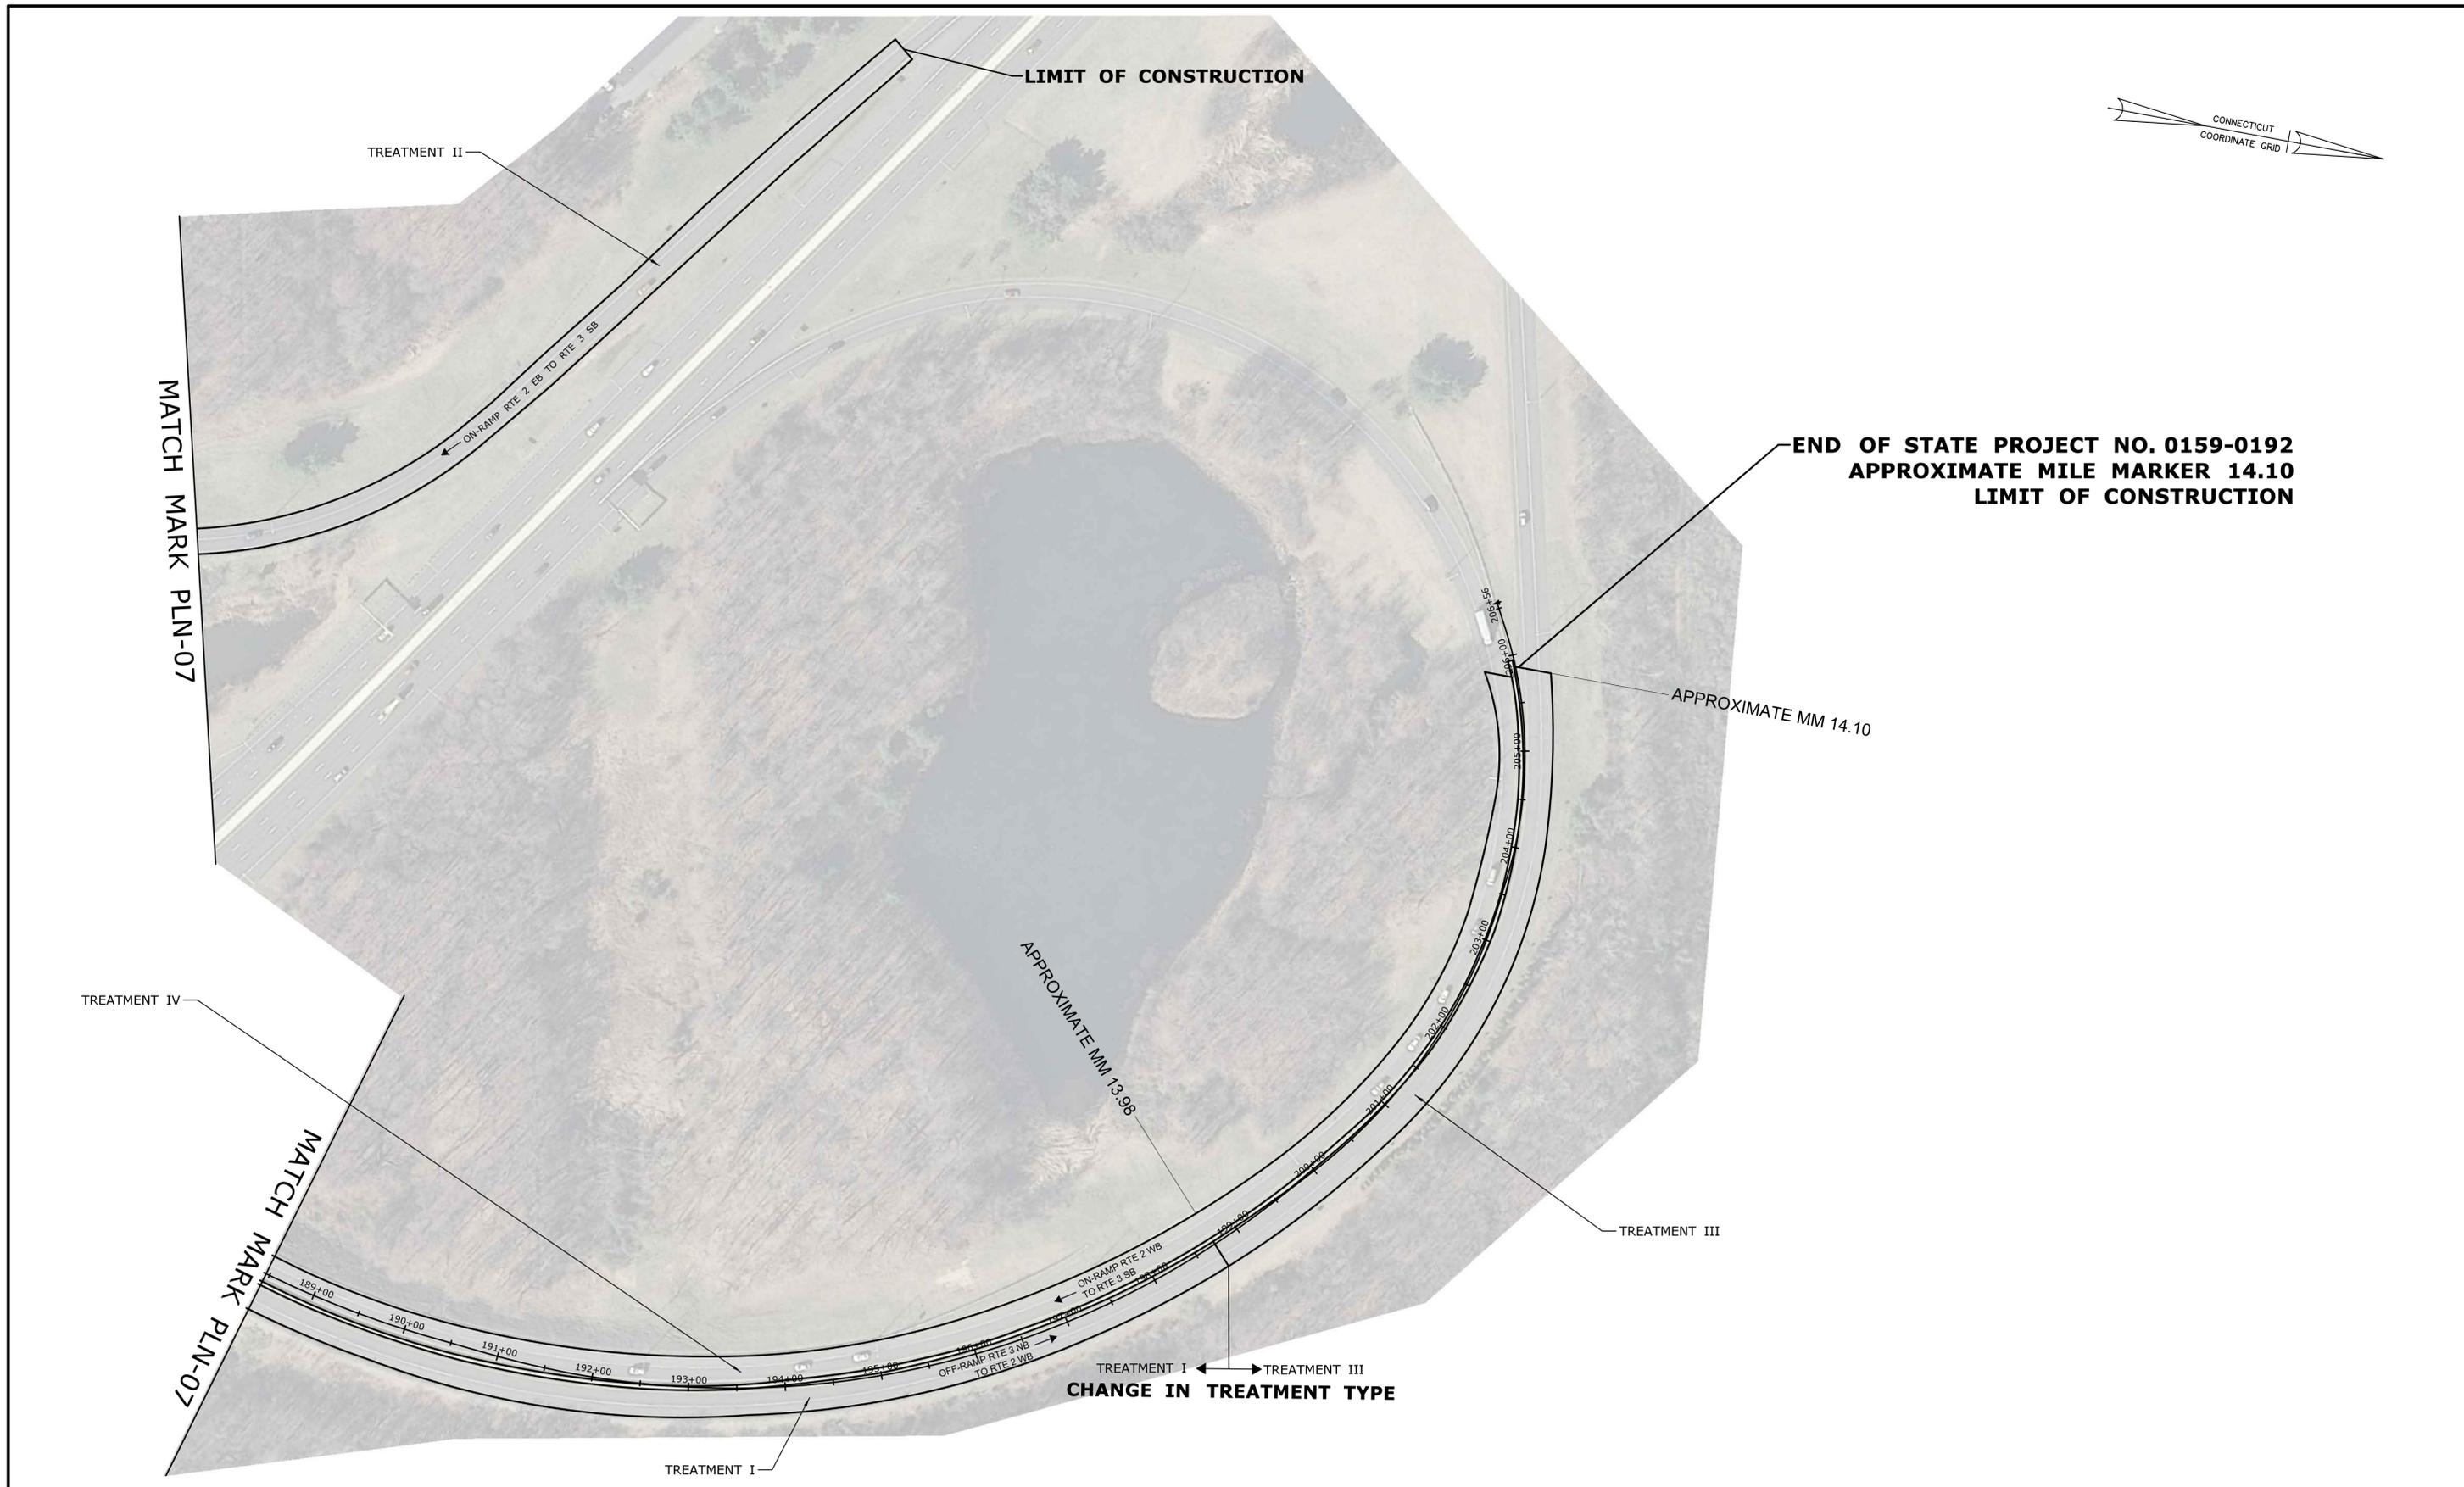

**END OF STATE PROJECT NO. 0159-0192
APPROXIMATE MILE MARKER 14.10
LIMIT OF CONSTRUCTION**

APPROXIMATE MM 14.10

APPROXIMATE MM 13.98


CHANGE IN TREATMENT TYPE

REV.	DATE	REVISION DESCRIPTION	SHEET NO.

THE INFORMATION, INCLUDING ESTIMATED QUANTITIES OF WORK, SHOWN ON THESE SHEETS IS BASED ON LIMITED INVESTIGATIONS BY THE STATE AND IS IN NO WAY WARRANTED TO INDICATE THE CONDITIONS OF ACTUAL QUANTITIES OF WORK WHICH WILL BE REQUIRED.

Plotted Date: 11/25/2015

DESIGNER/DRAFTER: JB
CHECKED BY: SN
SCALE IN FEET
0 80 160
SCALE 1"=80'

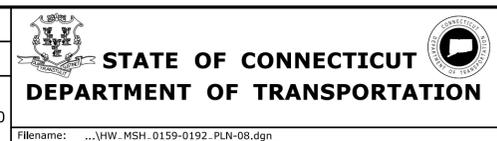

SIGNATURE/BLOCK:
OFFICE OF ENGINEERING
APPROVED BY:
Willie B. Butler

PROJECT TITLE:
**PAVEMENT PRESERVATION
OF ROUTE 3**

TOWN:
**WETHERSFIELD
GLASTONBURY**
DRAWING TITLE:
HIGHWAY PLAN

PROJECT NO.
159-192
DRAWING NO.
PLN-08
SHEET NO.
03.12